


Construction Drawings for RED LAKE WATERSHED DISTRICT

Thief River Falls Flood Damage Reduction Project and Improvement to Pennington County Ditch #1 (RLWD Ditch #14)

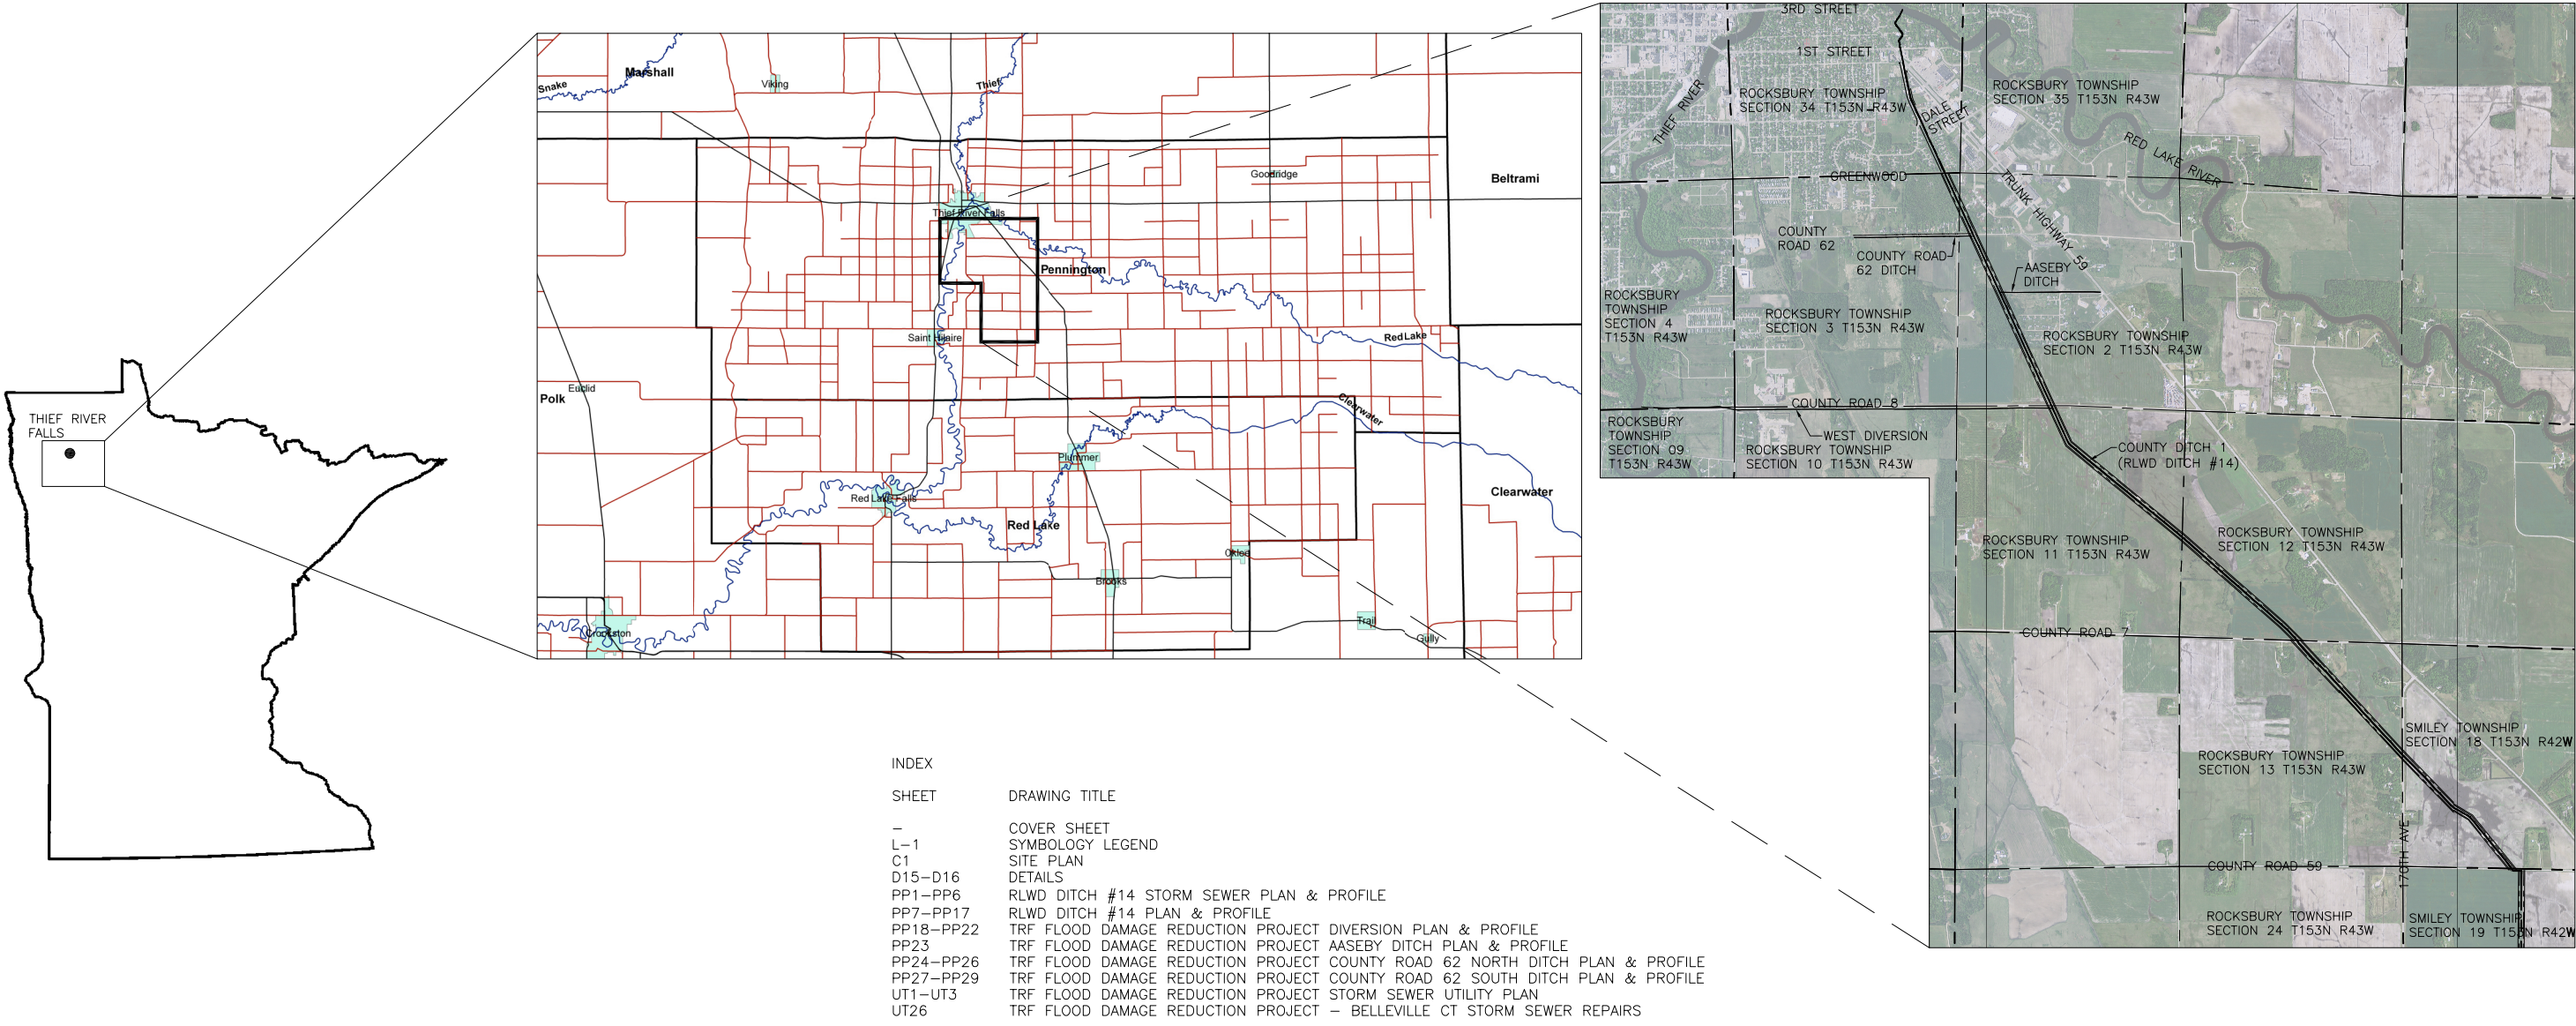

HDR Engineering, Inc.
324 Second Street East
Thief River Falls, MN 56701
Phone (218) 681-6100

AS-BUILT JANUARY 2013
HDR Project No. 131515

I HEREBY CERTIFY THAT THIS PLAN, SPECIFICATION, OR REPORT WAS PREPARED BY ME OR UNDER MY DIRECT SUPERVISION AND THAT I AM A DULY REGISTERED PROFESSIONAL ENGINEER UNDER THE LAWS OF THE STATE OF MINNESOTA.


DATE 1/21/2013 REG. NO. 25309

Nathan P. Dalager - P.E.



HDR

HDR Engineering, Inc.
 324 2nd St. E.
 Thief River Falls, MN 56701
 (218) 681 - 6100

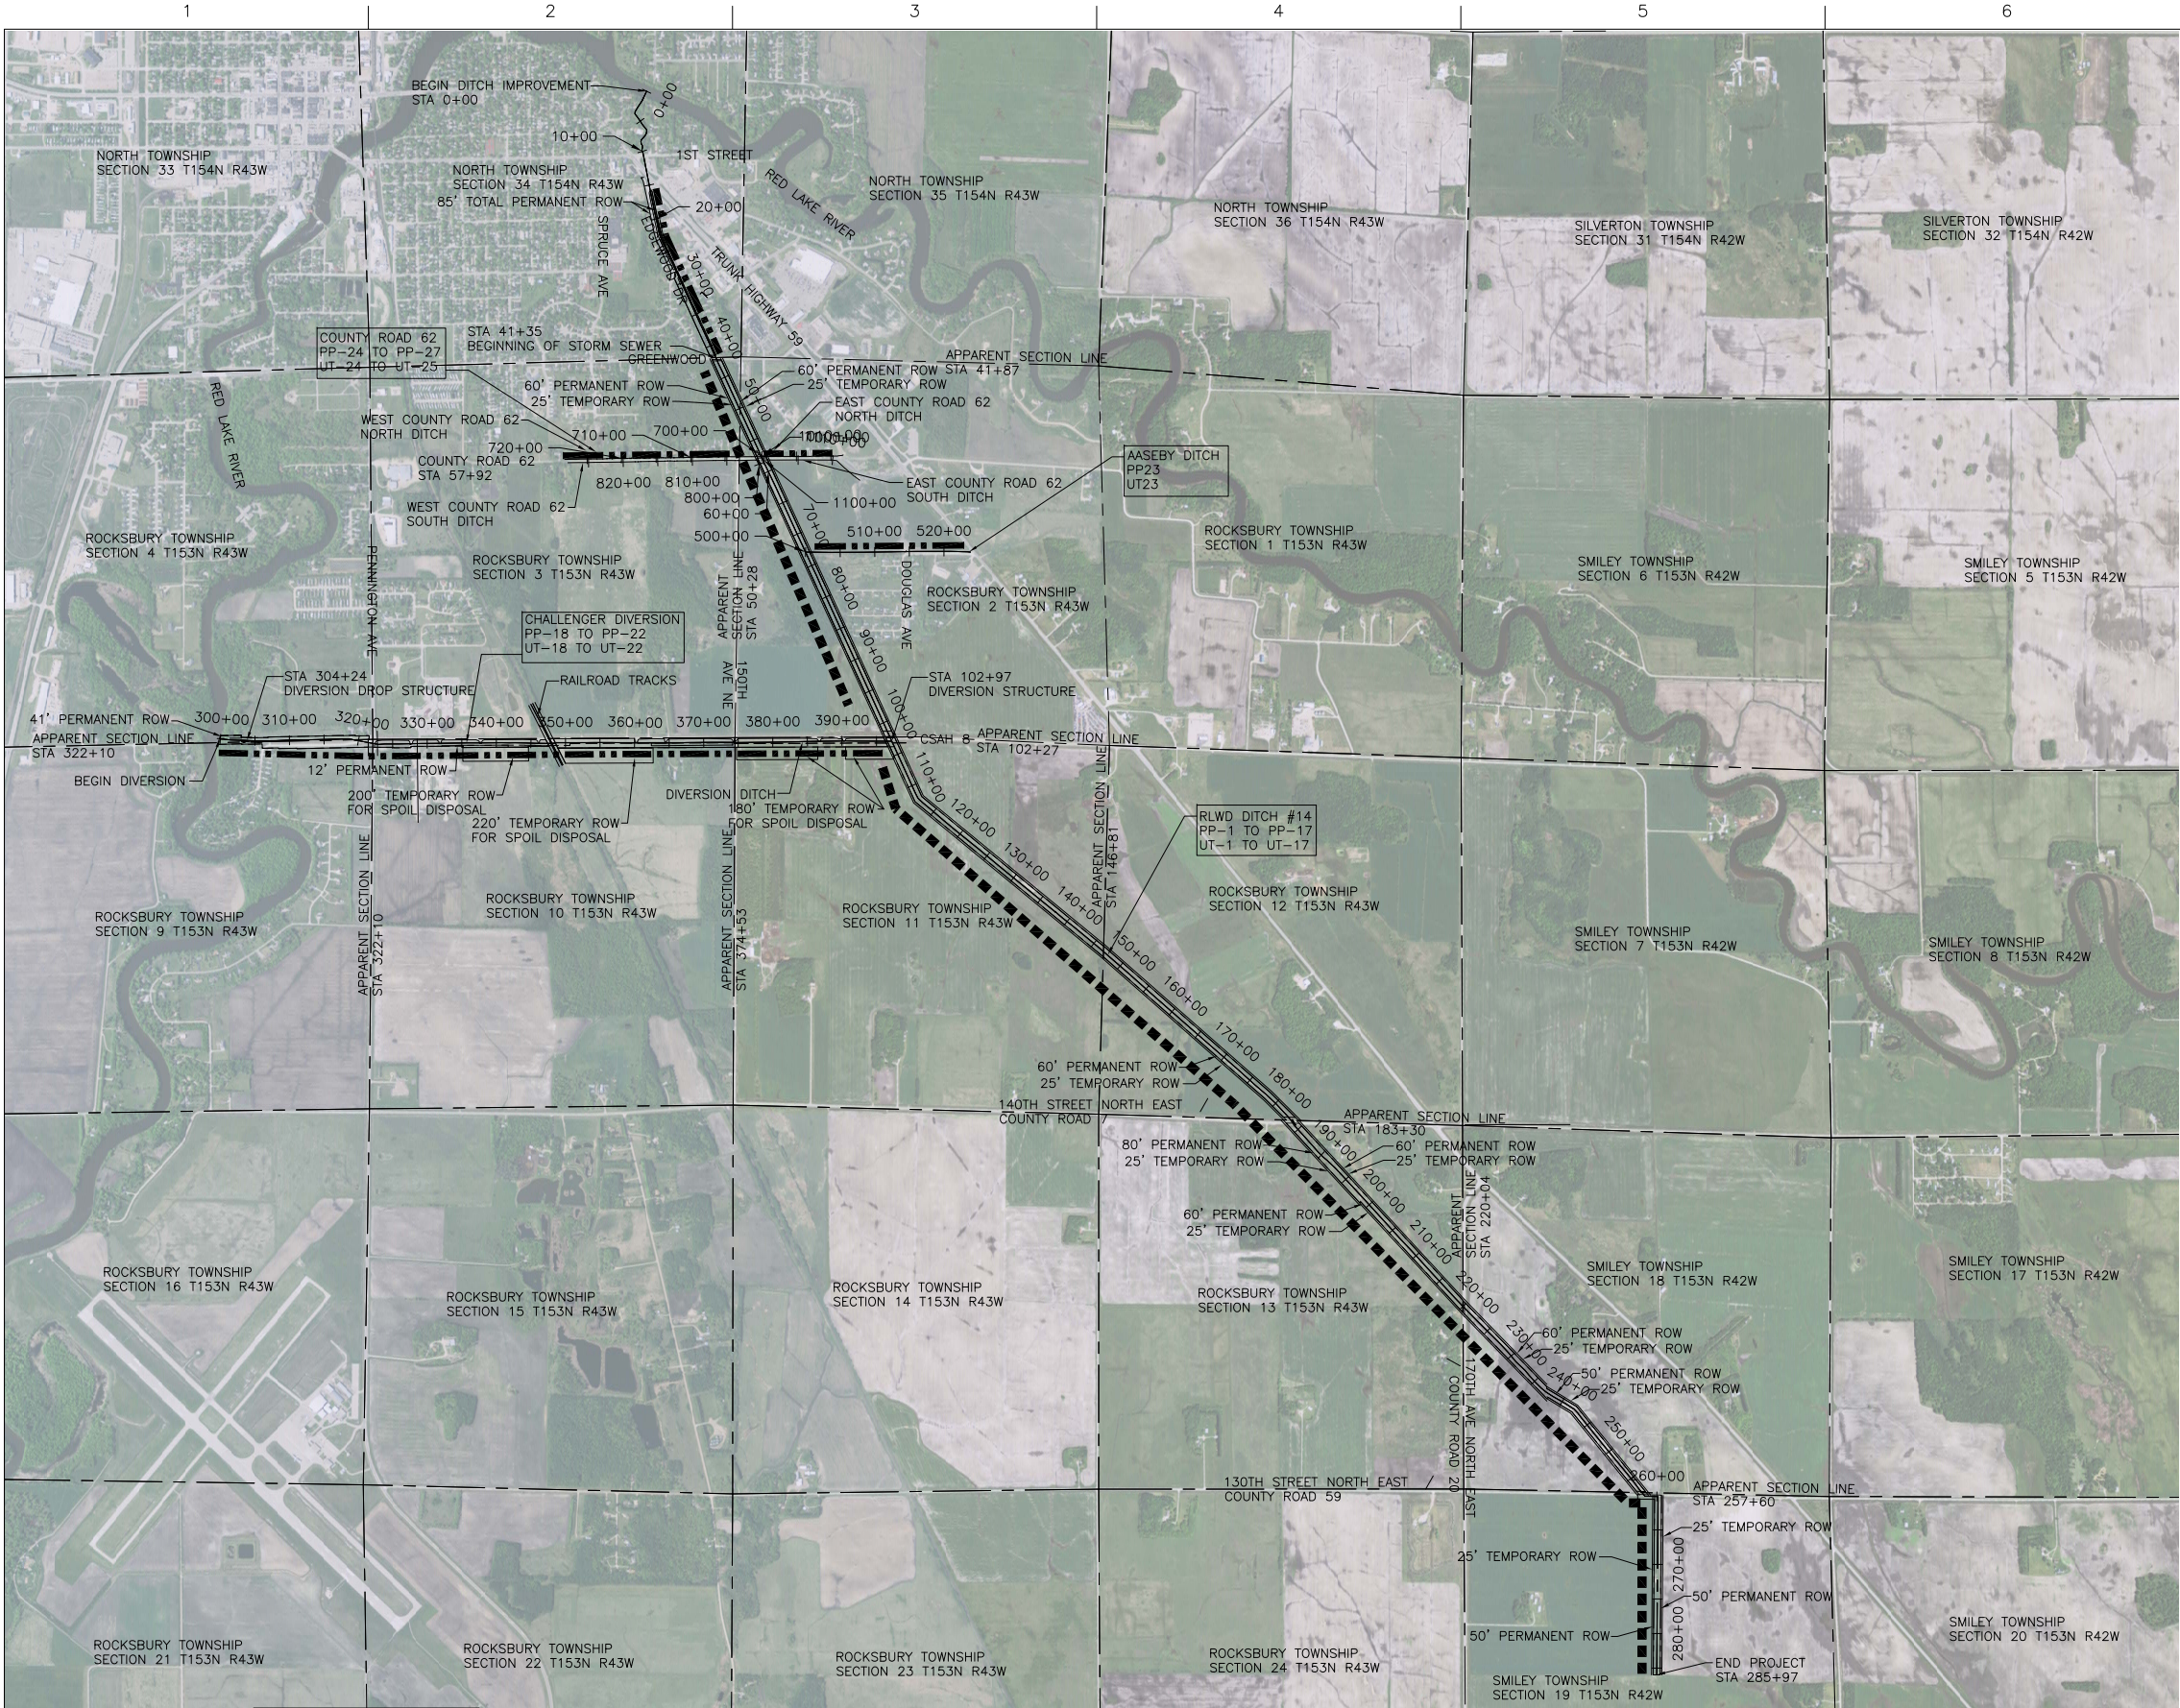

BENCHMARK & GPS CONTROL
MN / DOT GEODETIC DATA BASE STATION 23020
VERTICAL DATUM NAVD 88
NORTHING - 562400.973 (X)
EASTING - 310712.816 (Y)
ELEVATION - 1131.185 (Z)
COORDINATE SYSTEM - COUNTY COORDINATES

4.0 MILES SOUTHEAST OF THIEF RIVER FALLS, 4.7 MILES SOUTHEAST ON TRUNK HIGHWAY 59 FROM JUNCTION OF TRUNK HIGHWAY 59 AND TRUNK HIGHWAY 32 AT THIEF RIVER FALLS, 3.2 FEET SOUTH OF WITNESS POST, 38.42 FEET NORTH OF REFERENCE MARK 1, 103 FEET SOUTHWEST OF TRUNK HIGHWAY 59 AT MILE POINT 353.8, 111.0 FEET EAST OF POLE, 142.6 FEET SOUTHEAST OF CABLE PEDESTAL.

LEGEND	
	RLWD #14 (COUNTY DITCH 1) IMPROVEMENT
	TRF FLOOD DAMAGE REDUCTION PROJECT

ALIGNMENT NAME	STATION
COUNTY DITCH 1	0+00 TO 285+97
CHALLENGER DIVERSION	300+00 TO 397+21
AASEBY DITCH	500+00 TO 523+80
WEST COUNTY ROAD 62 NORTH DITCH	700+00 TO 728+27
WEST COUNTY ROAD 62 SOUTH DITCH	800+00 TO 827+98
EAST COUNTY ROAD 62 NORTH DITCH	1000+00 TO 1011+83
EAST COUNTY ROAD 62 SOUTH DITCH	1100+00 TO 1114+97



HDR Engineering, Inc.
324 2nd St. E.
Thief River Falls, MN 56701
(218) 681-6100

ISSUE	DATE	DESCRIPTION

PROJECT MANAGER	Nate Dalager
DESIGNED	G. Hufnagle
DESIGNED	R. Knott
CHECKED	M. Peterson
CHECKED	M. Redington
DRAWN	
DRAWN	
PROJECT NUMBER	131515

 
I HEREBY CERTIFY THAT THIS PLAN, SPECIFICATION, OR REPORT WAS PREPARED BY ME OR UNDER MY DIRECT SUPERVISION AND THAT I AM A DULY REGISTERED PROFESSIONAL ENGINEER UNDER THE LAWS OF THE STATE OF MINNESOTA.

DATE 1/21/2013 REG. NO. 25309
Nathan P. Dalager
Nathan P. Dalager


Red Lake Watershed District
1000 PENNINGTON AVE.
THIEF RIVER FALLS, MN 56701
(218) 681-5800

THIEF RIVER FALLS FLOOD DAMAGE REDUCTION PROJECT AND IMPROVEMENT TO PENNINGTON COUNTY DITCH #1 (RLWD DITCH #14)




TRF FLOOD DAMAGE REDUCTION PROJECT AND RLWD DITCH #14
SITE PLAN AND R.O.W.
AS-BUILT - JANUARY 2013



FILENAME	00C-SP-01.dwg
SHEET	C-1

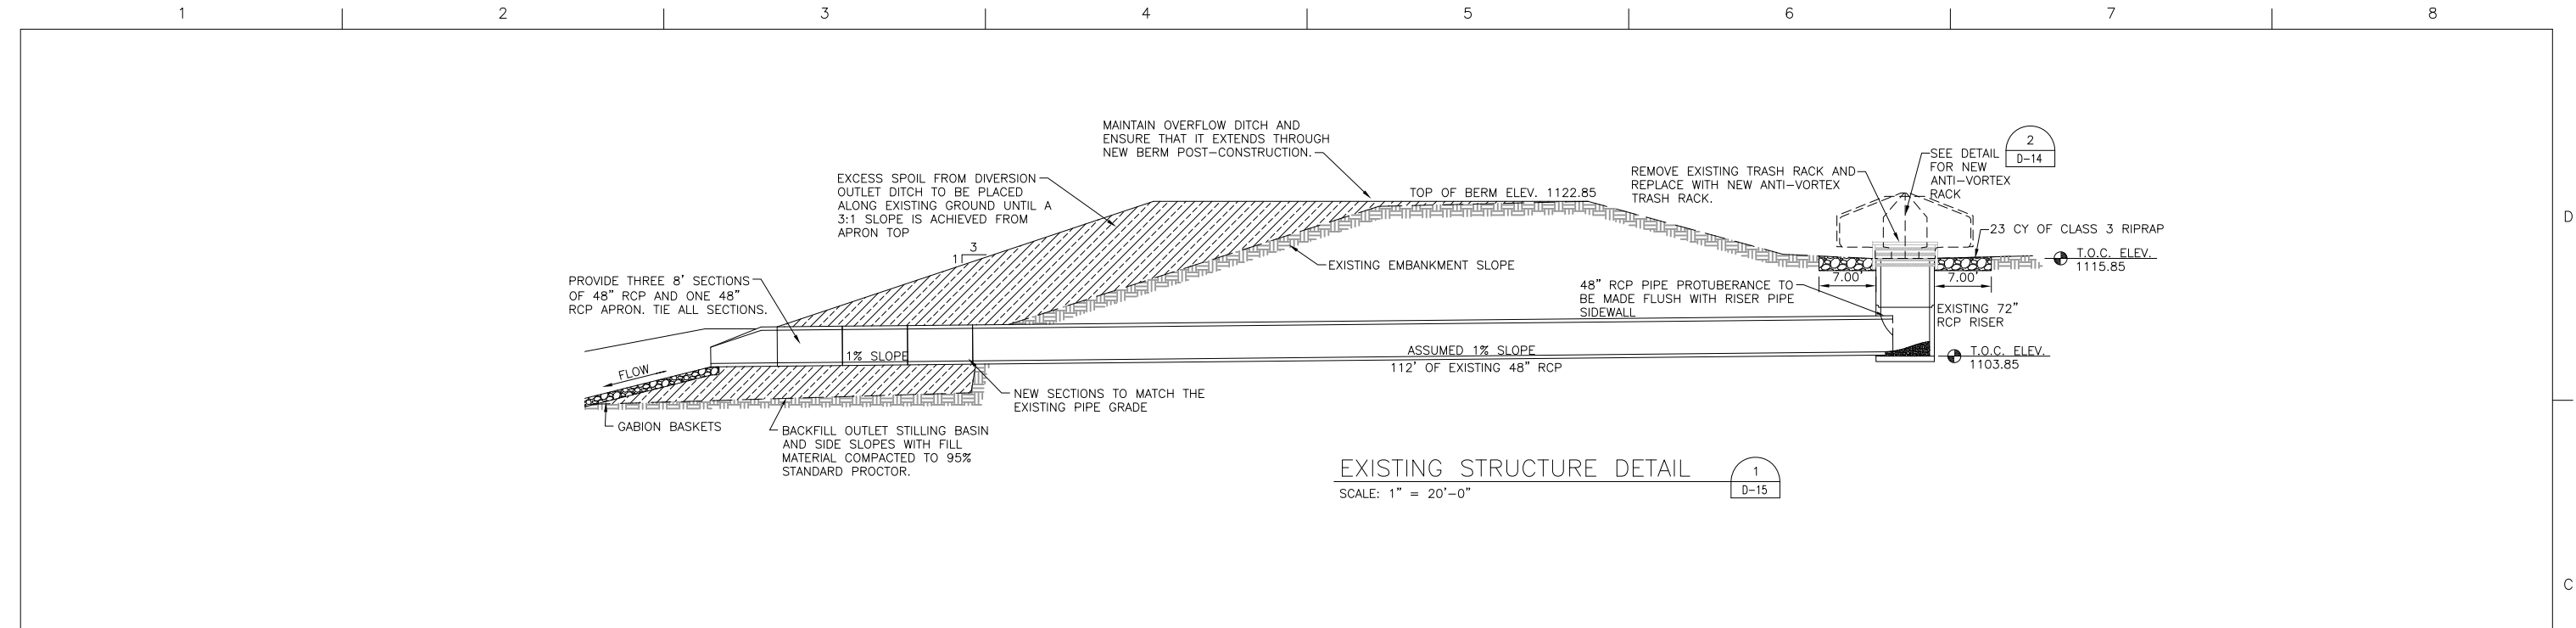

SEE PAGE D-16 FOR DIVERSION STRUCTURE
DESIGN MODIFICATION DETAILS

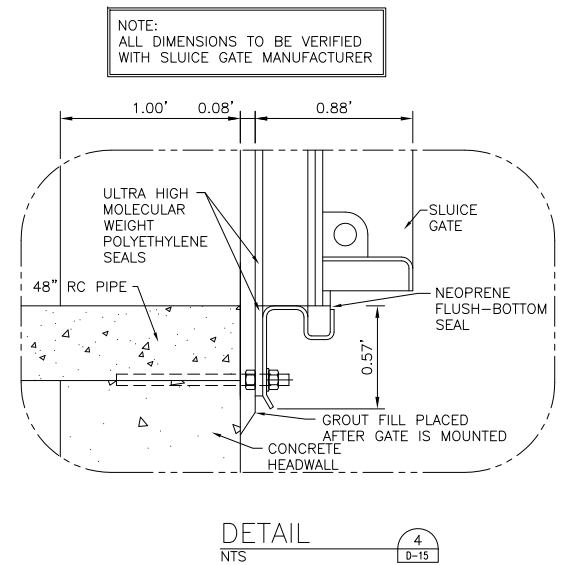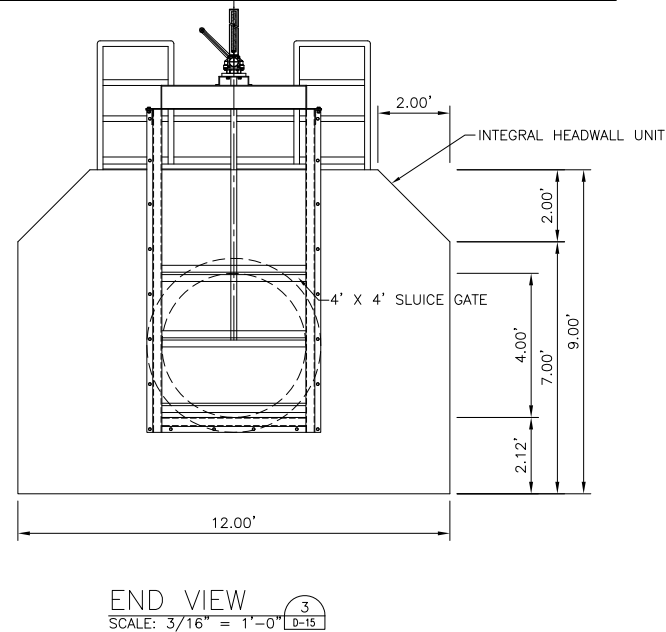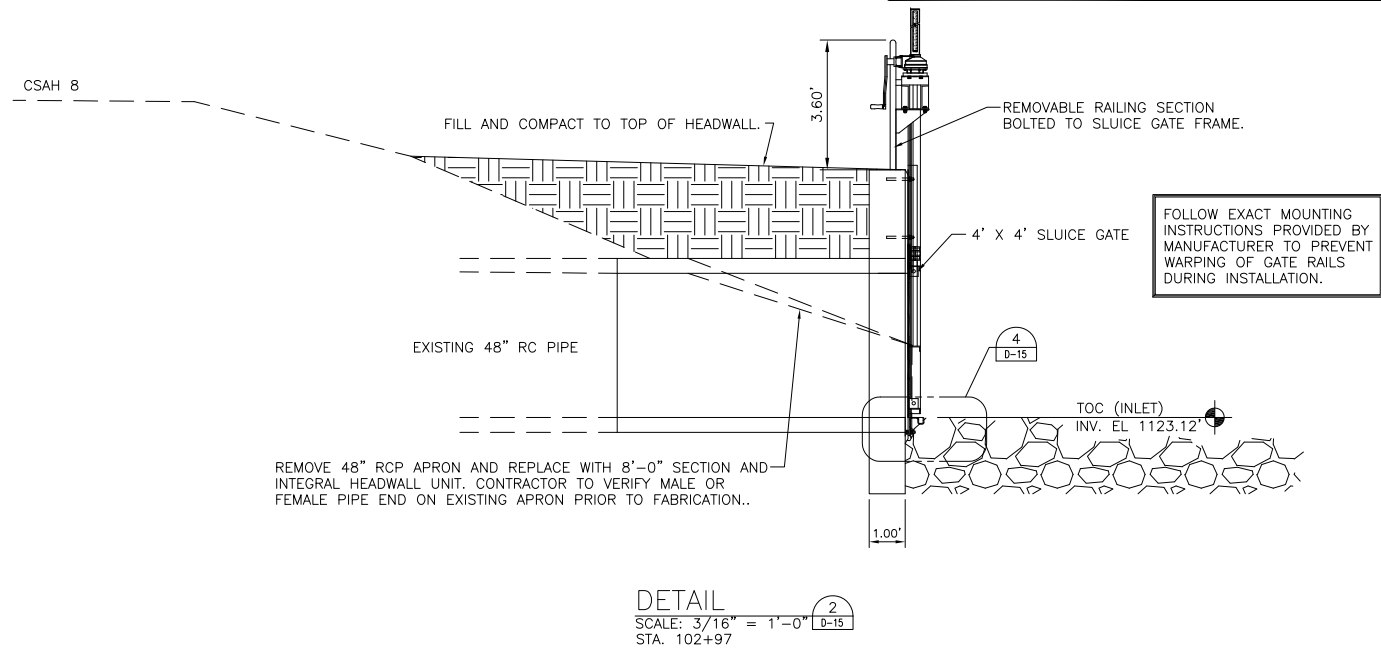

			PROJECT MANAGER	Nathan P. Dalager
			DESIGNED	M. Peterson
			DESIGNED	R. Knott
			CHECKED	G. Hufnagle
			CHECKED	M. Redington
			DRAWN	
			DRAWN	
ISSUE	DATE	DESCRIPTION	PROJECT NUMBER	131515

I HEREBY CERTIFY THAT THIS PLAN, SPECIFICATION, OR REPORT WAS PREPARED BY ME OR UNDER MY DIRECT SUPERVISION AND THAT I AM A DULY REGISTERED PROFESSIONAL ENGINEER UNDER THE LAWS OF THE STATE OF MINNESOTA.

DATE 1/21/2013 REG. NO. 25309

Nathan P. Dalager

Nathan P. Dalager

Red Lake Watershed District



1000 PENNINGTON AVE.
THIEF RIVER FALLS, MN
56701 (218) 681-5800

THIEF RIVER FALLS FLOOD DAMAGE REDUCTION PROJECT AND IMPROVEMENT TO PENNINGTON COUNTY DITCH #1 (RLWD DITCH #14)

TRF FLOOD DAMAGE REDUCTION PROJECT
DIVERSION STRUCTURE AND EXISTING
OUTLET STRUCTURE MODIFICATIONS
AS-BUILT - JANUARY 2013

0 1/2" 1"



FILENAME OOC-DT02-05.dwg SHEET D-15

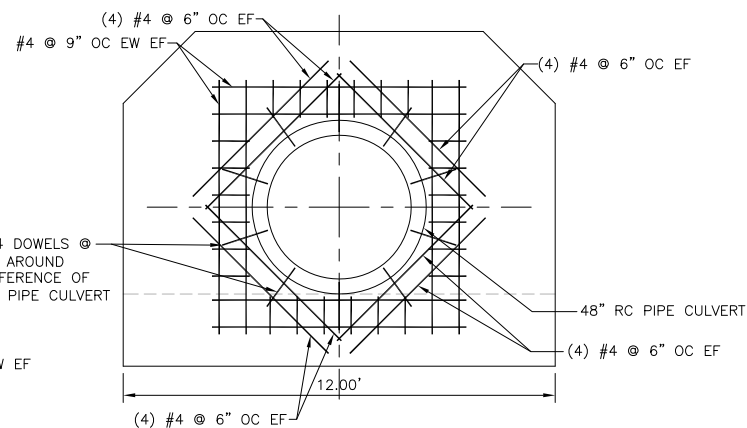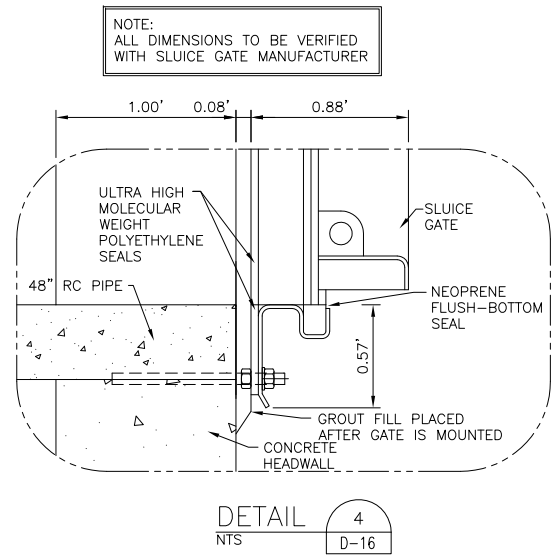


REINFORCEMENT OF
OPENING DETAIL

SCALE: NOT TO SCALE

8
-

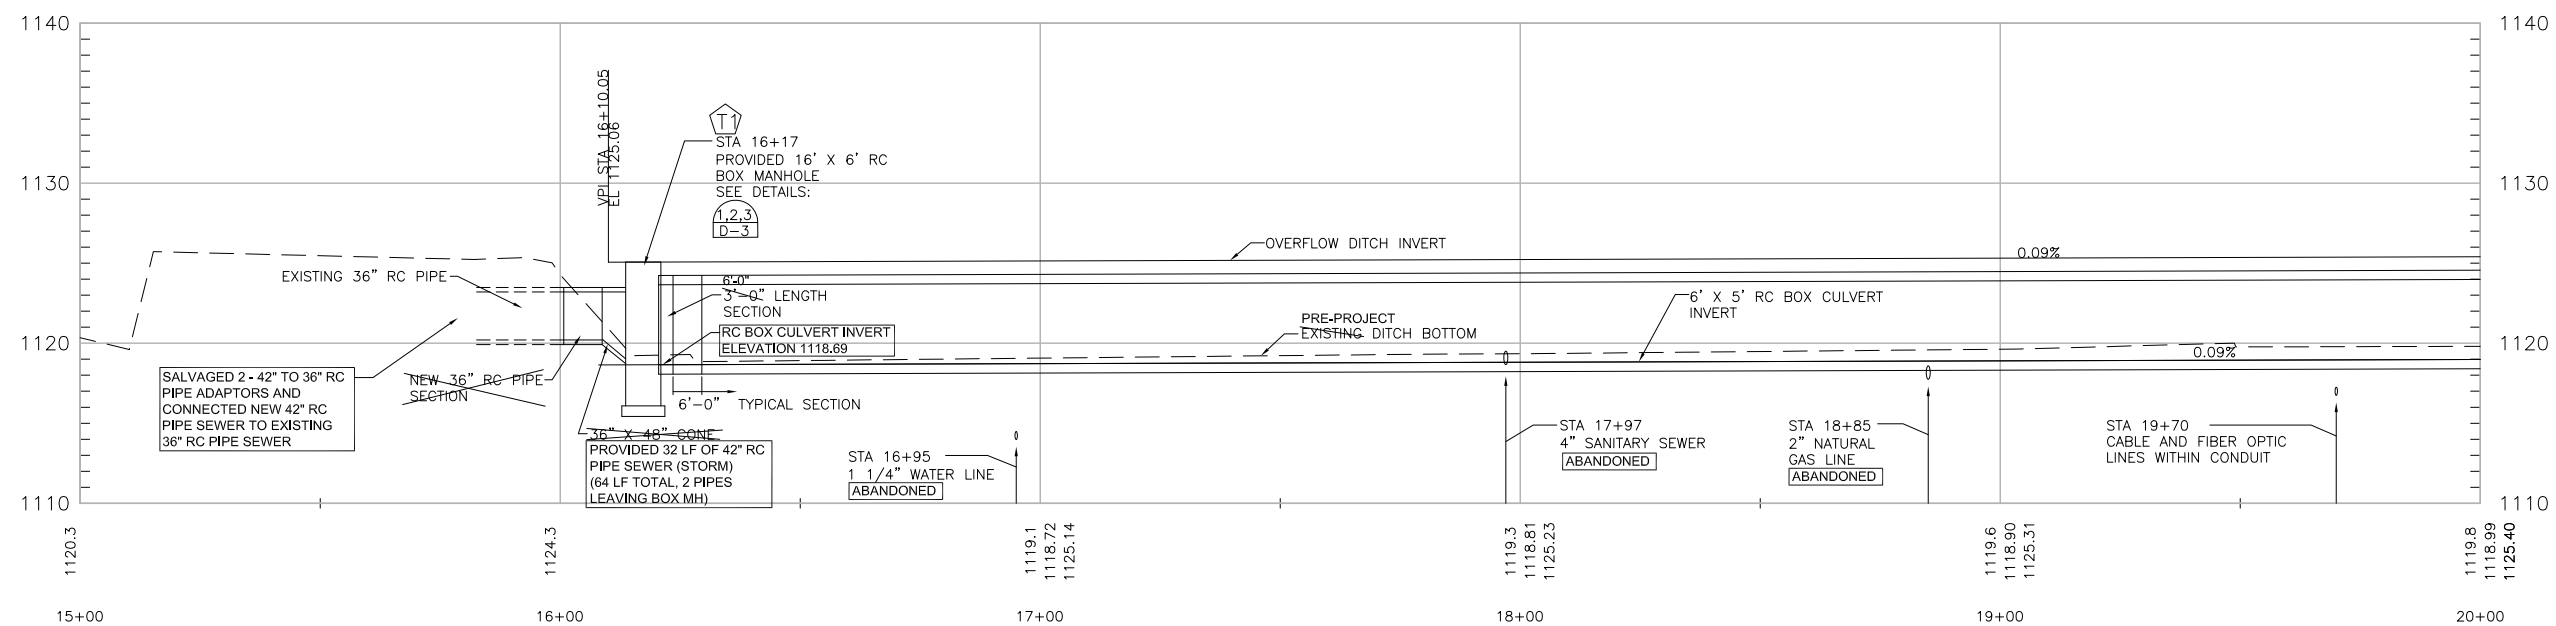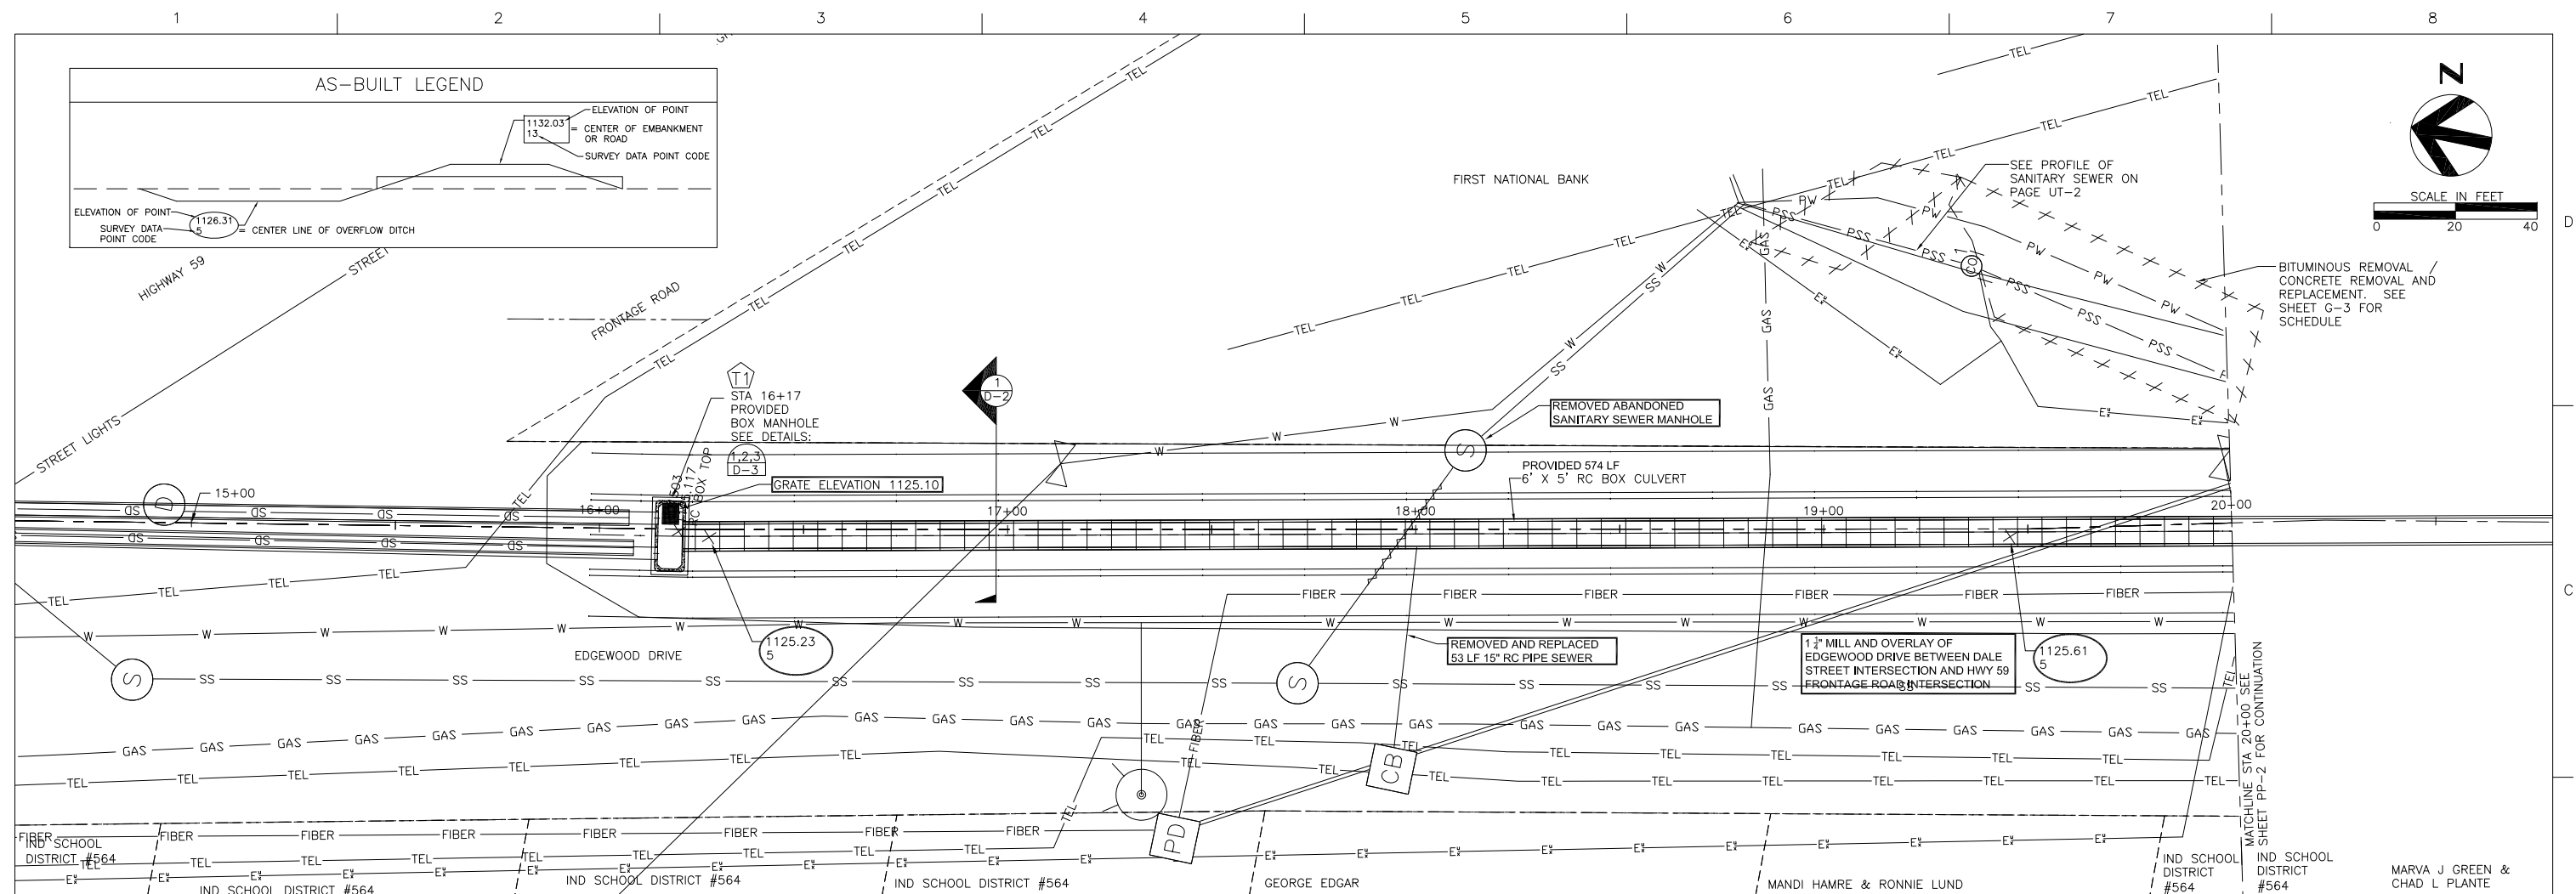

NOTE:
SEE UT-1 FOR UTILITY
COORDINATION AND
RELOCATION INSTRUCTIONS

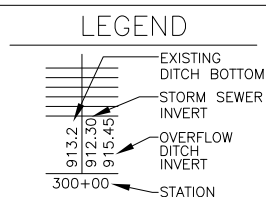

HDR Engineering, Inc.
324 2nd St. E.
Thief River Falls, MN 56701
(218) 681-6100

			PROJECT MANAGER	Nathan P. Dalager
			DESIGNED	G. Hufnagle
			DESIGNED	M. Peterson
			CHECKED	R. Knott
			CHECKED	M. Redington
			DRAWN	
			DRAWN	
ISSUE	DATE	DESCRIPTION	PROJECT NUMBER	131515

I HEREBY CERTIFY THAT THIS PLAN,
SPECIFICATION, OR REPORT WAS
PREPARED BY ME OR UNDER MY
DIRECT SUPERVISION AND THAT I AM
A DULY REGISTERED PROFESSIONAL
ENGINEER UNDER THE LAWS OF THE
STATE OF MINNESOTA.

DATE 1/21/2013 REG. NO. 25309

 
Nathan P. Dalager
Nathan P. Dalager

Red Lake
Watershed District

1000 PENNINGTON AVE.
THIEF RIVER FALLS, MN
56701 (218) 681-5800



THIEF RIVER FALLS FLOOD DAMAGE REDUCTION
PROJECT AND IMPROVEMENT TO PENNINGTON
COUNTY DITCH #1 (RLWD DITCH #14)

RLWD DITCH #14
STORM SEWER PLAN AND PROFILE
STA 15+00 TO 20+00
AS-BUILT - JANUARY 2013




FILENAME	00C-PP05-01.dwg
----------	-----------------

SHEET
PP-1

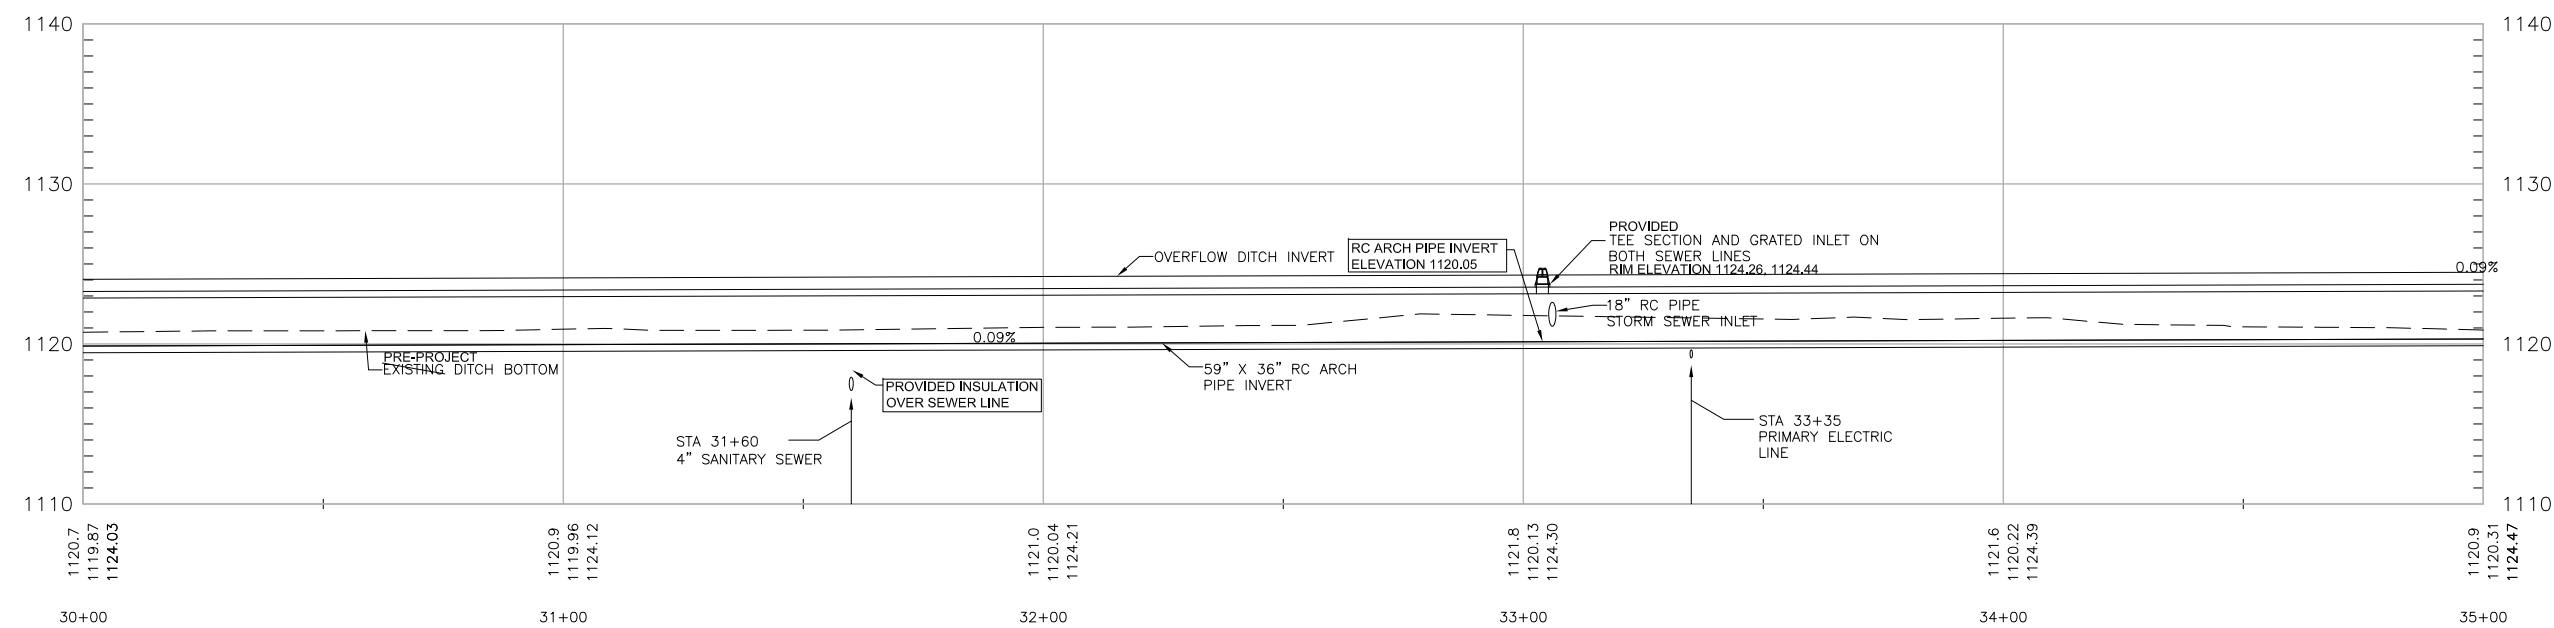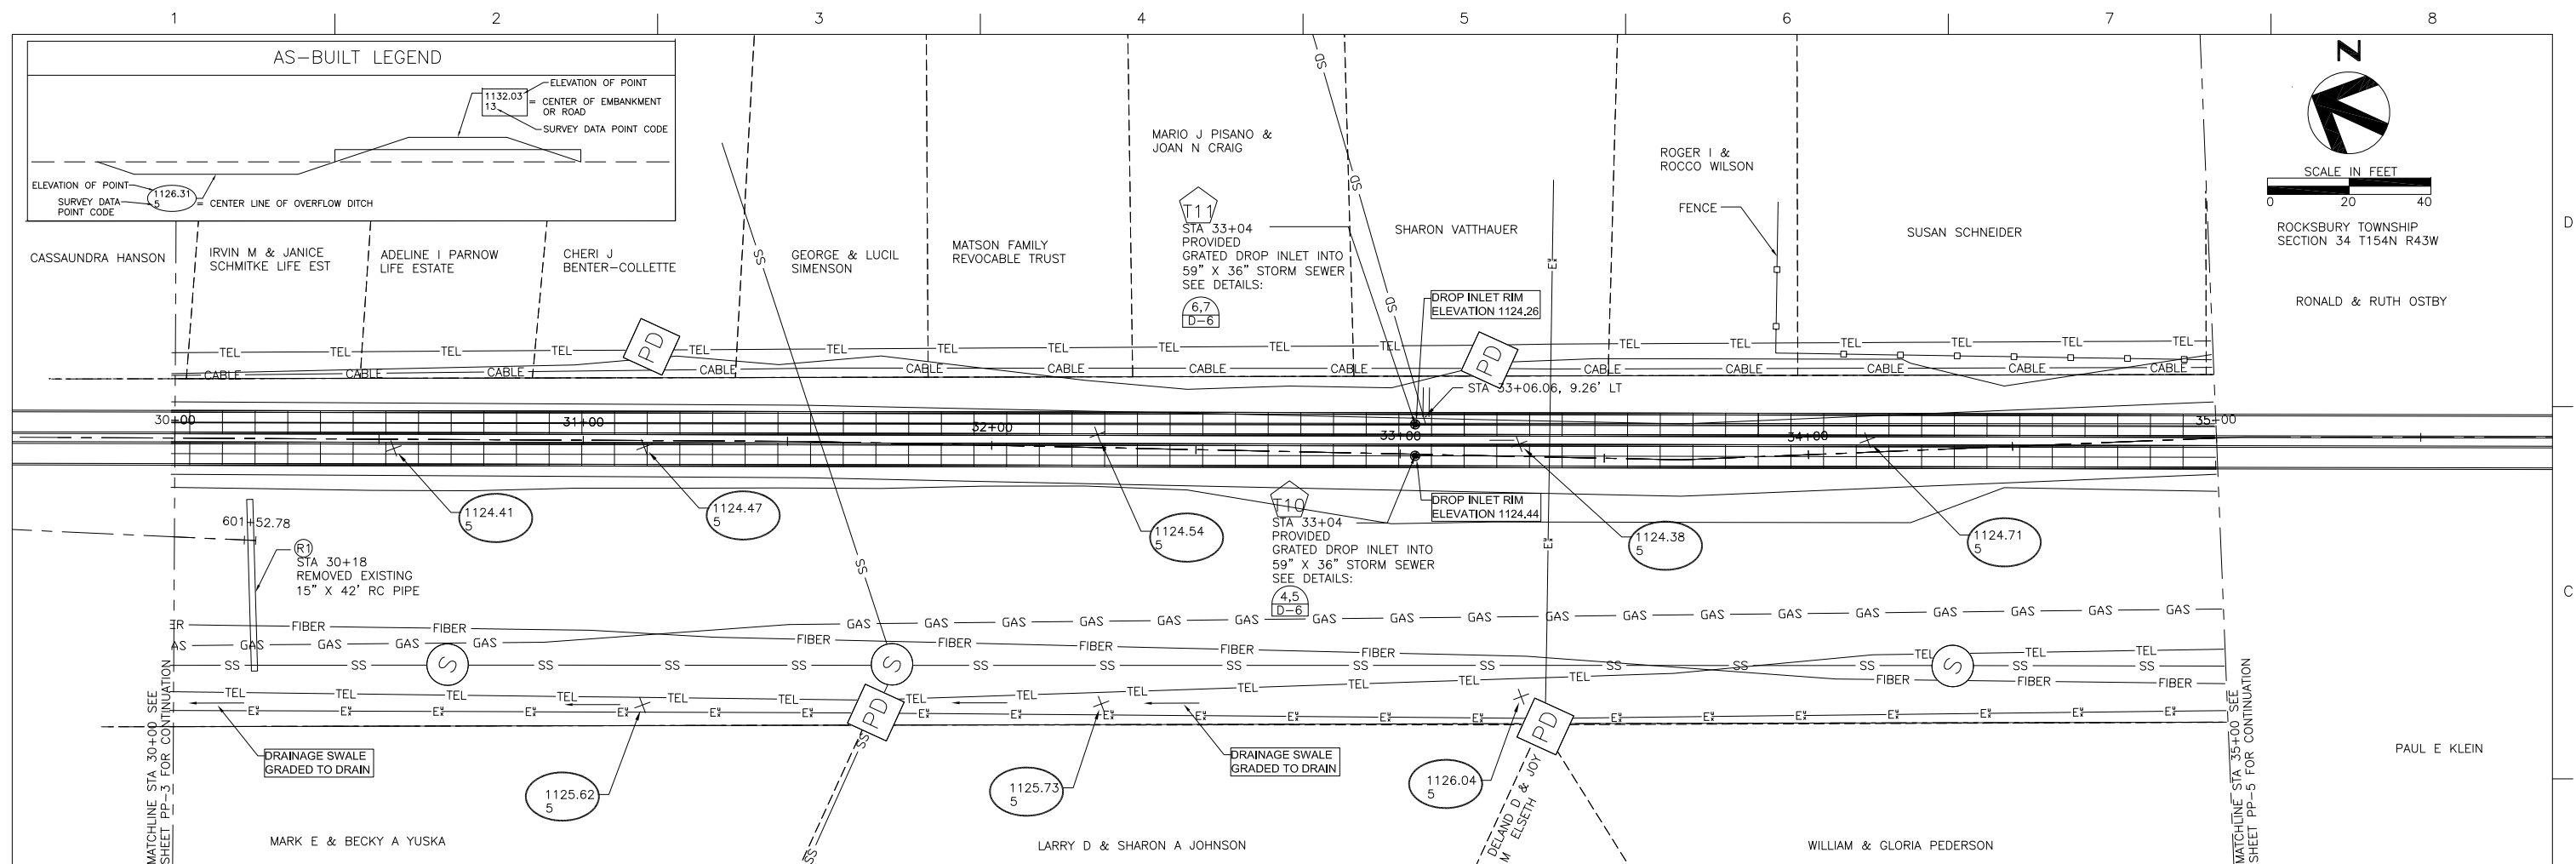

NOTE:
SEE UT-4 FOR UTILITY
COORDINATION AND
RELOCATION INSTRUCTIONS

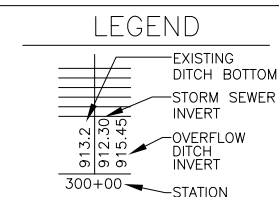

HDR Engineering, Inc.
324 2nd St. E.
Thief River Falls, MN 56701
(218) 681 - 6100

			PROJECT MANAGER	Nathan P. Dalager
			DESIGNED	G. Hufnagle
			DESIGNED	M. Peterson
			CHECKED	R. Knott
			CHECKED	M. Redington
			DRAWN	
			DRAWN	
ISSUE	DATE	DESCRIPTION	PROJECT NUMBER	131515

I HEREBY CERTIFY THAT THIS PLAN, SPECIFICATION, OR REPORT WAS PREPARED BY ME OR UNDER MY DIRECT SUPERVISION AND THAT I AM A DULY REGISTERED PROFESSIONAL ENGINEER UNDER THE LAWS OF THE STATE OF MINNESOTA.

DATE 1/21/2013 REG. NO. 25309

Nathan P. Dalager
Nathan P. Dalager

Red Lake
Watershed District

1000 PENNINGTON AVE.
THIEF RIVER FALLS, MN
56701 (218) 681-5800



THIEF RIVER FALLS FLOOD DAMAGE REDUCTION
PROJECT AND IMPROVEMENT TO PENNINGTON
COUNTY DITCH #1 (RLWD DITCH #14)

RLWD DITCH #14
STORM SEWER PLAN AND PROFILE
STA 30+00 TO 35+00
AS-BUILT - JANUARY 2013




FILENAME	00C-PP05-04.dwg
----------	-----------------

SHEET
PP-4

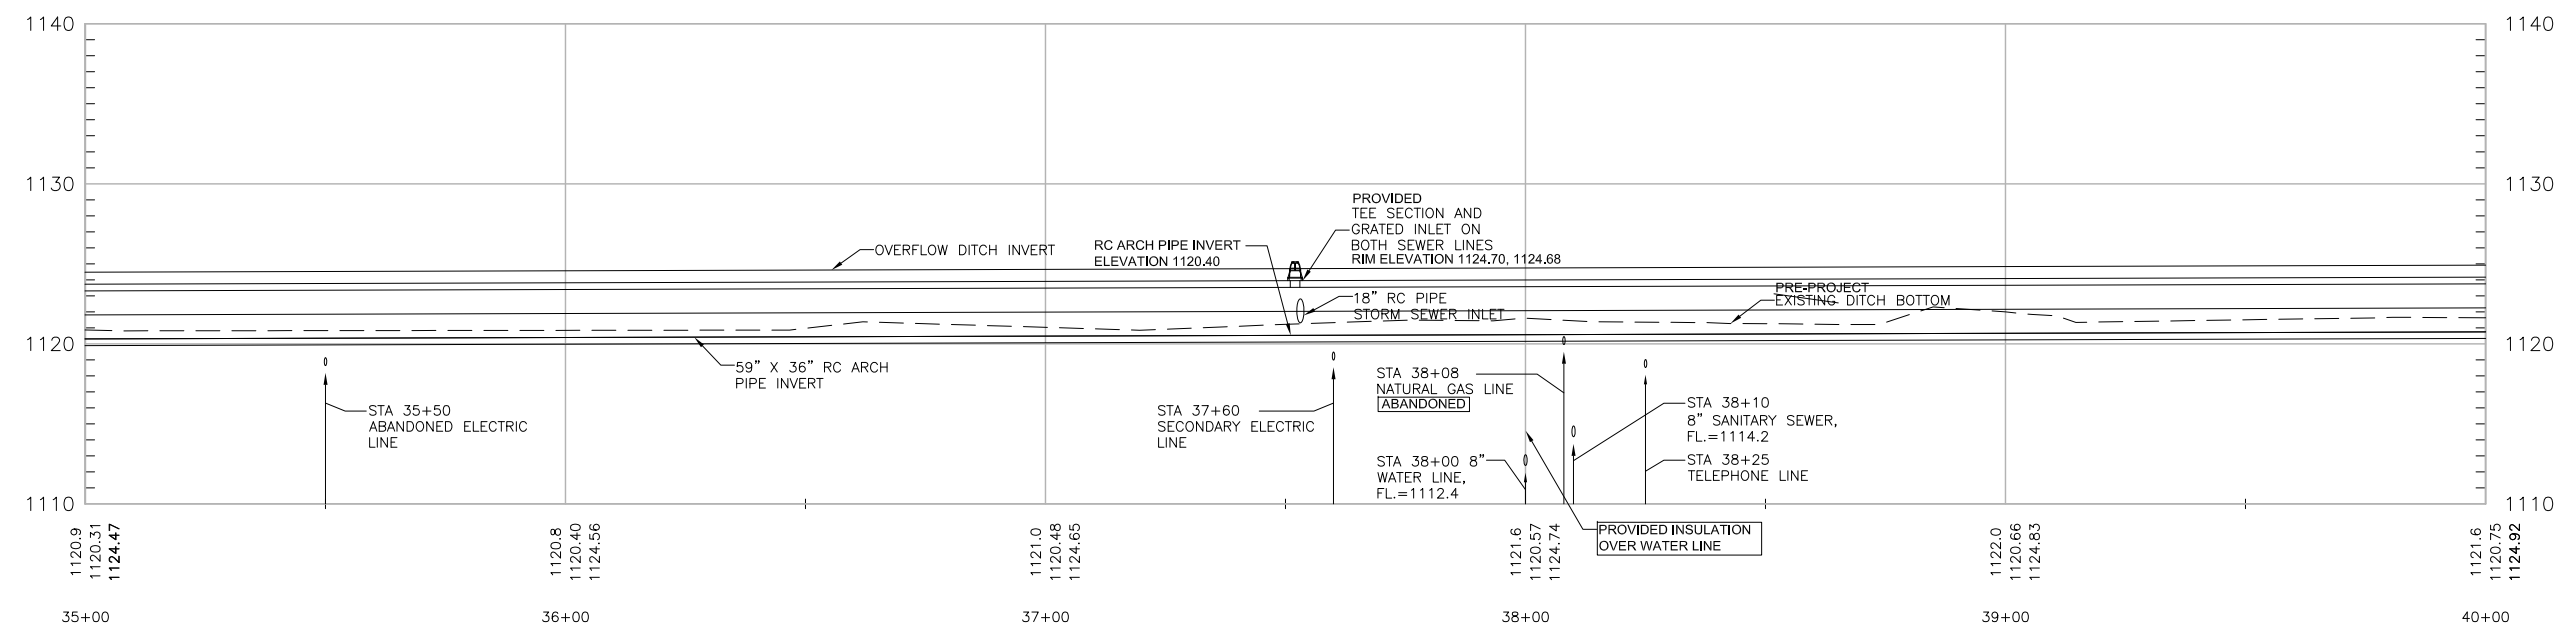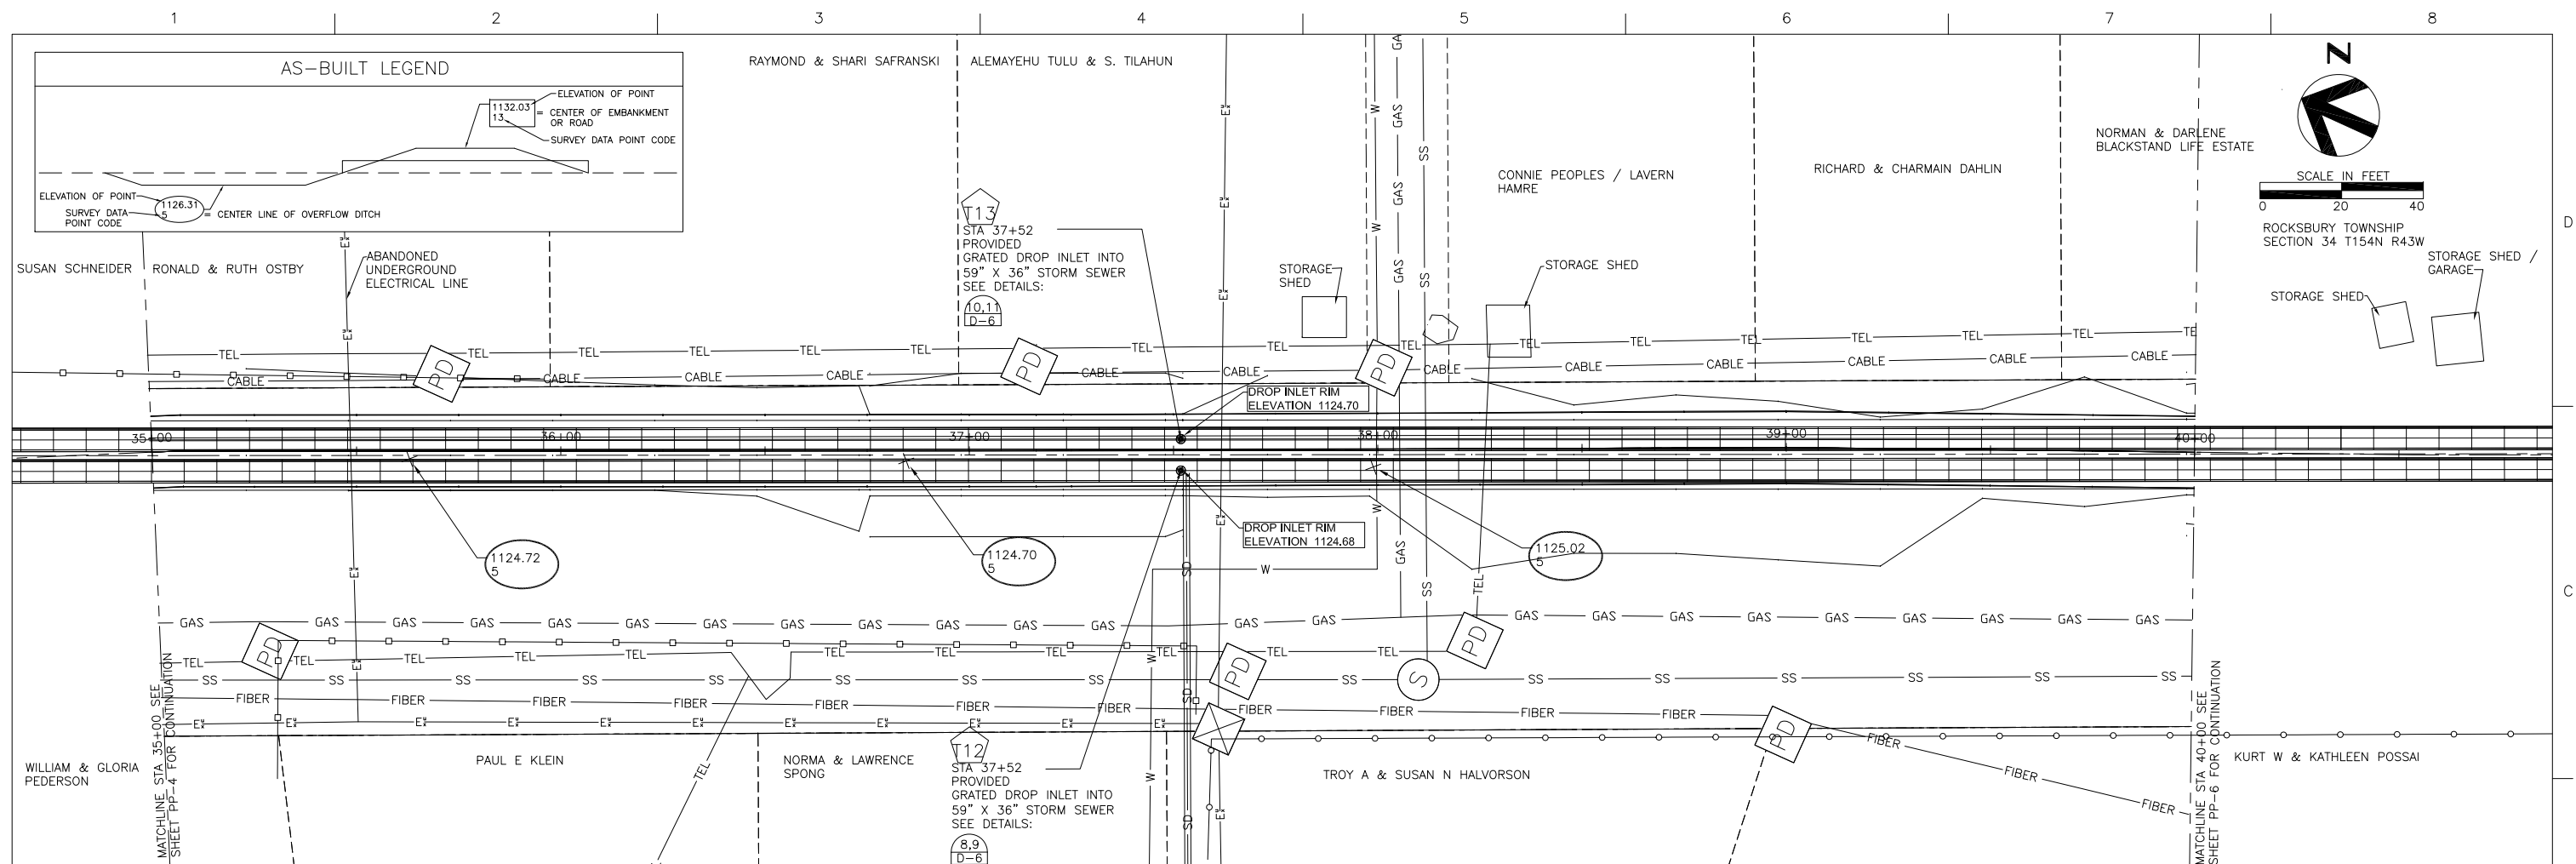

NOTE:
SEE UT-5 FOR UTILITY
COORDINATION AND
RELOCATION INSTRUCTIONS

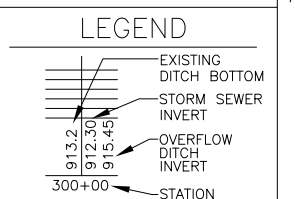

HDR Engineering, Inc.
324 2nd St. E.
Thief River Falls, MN 56701
(218) 681 - 6100

[illegible]

PROJECT MANAGER	Nathan P. Dalager
DESIGNED	G. Hufnagle
DESIGNED	M. Peterson
CHECKED	R. Knott
CHECKED	M. Redington
DRAWN	
DRAWN	
PROJECT NUMBER	131515

I HEREBY CERTIFY THAT THIS PLAN,
SPECIFICATION, OR REPORT WAS
PREPARED BY ME OR UNDER MY
DIRECT SUPERVISION AND THAT I AM
A DULY REGISTERED PROFESSIONAL
ENGINEER UNDER THE LAWS OF THE
STATE OF MINNESOTA.

DATE 1/21/2013 REG. NO. 25309

 
Nathan P. Dalager
Nathan P. Dalager

Red Lake
Watershed District

1000 PENNINGTON AVE.
THIEF RIVER FALLS, MN
56701 (218) 681-5800




THIEF RIVER FALLS FLOOD DAMAGE REDUCTION
PROJECT AND IMPROVEMENT TO PENNINGTON
COUNTY DITCH #1 (RLWD DITCH #14)

RLWD DITCH #14
STORM SEWER PLAN AND PROFILE
STA 35+00 TO 40+00
AS-BUILT - JANUARY 2013



FILE NAME	00C-PP05-05.dwg
-----------	-----------------

PP-5

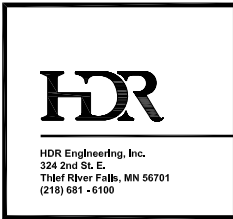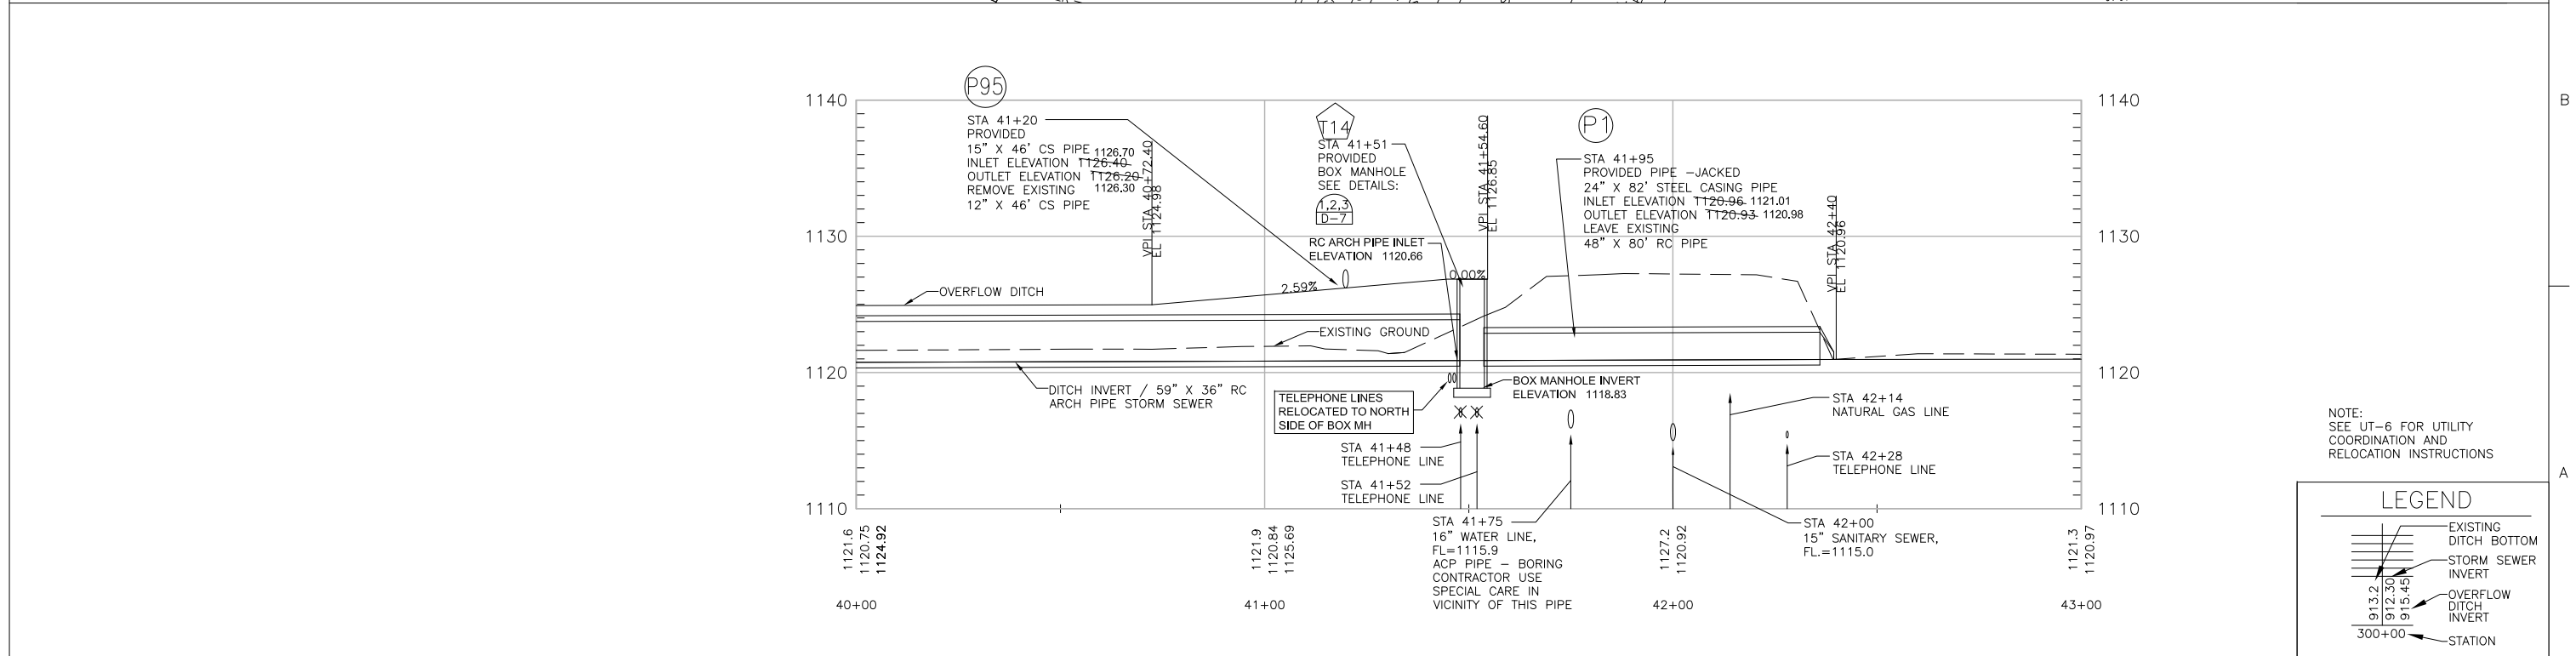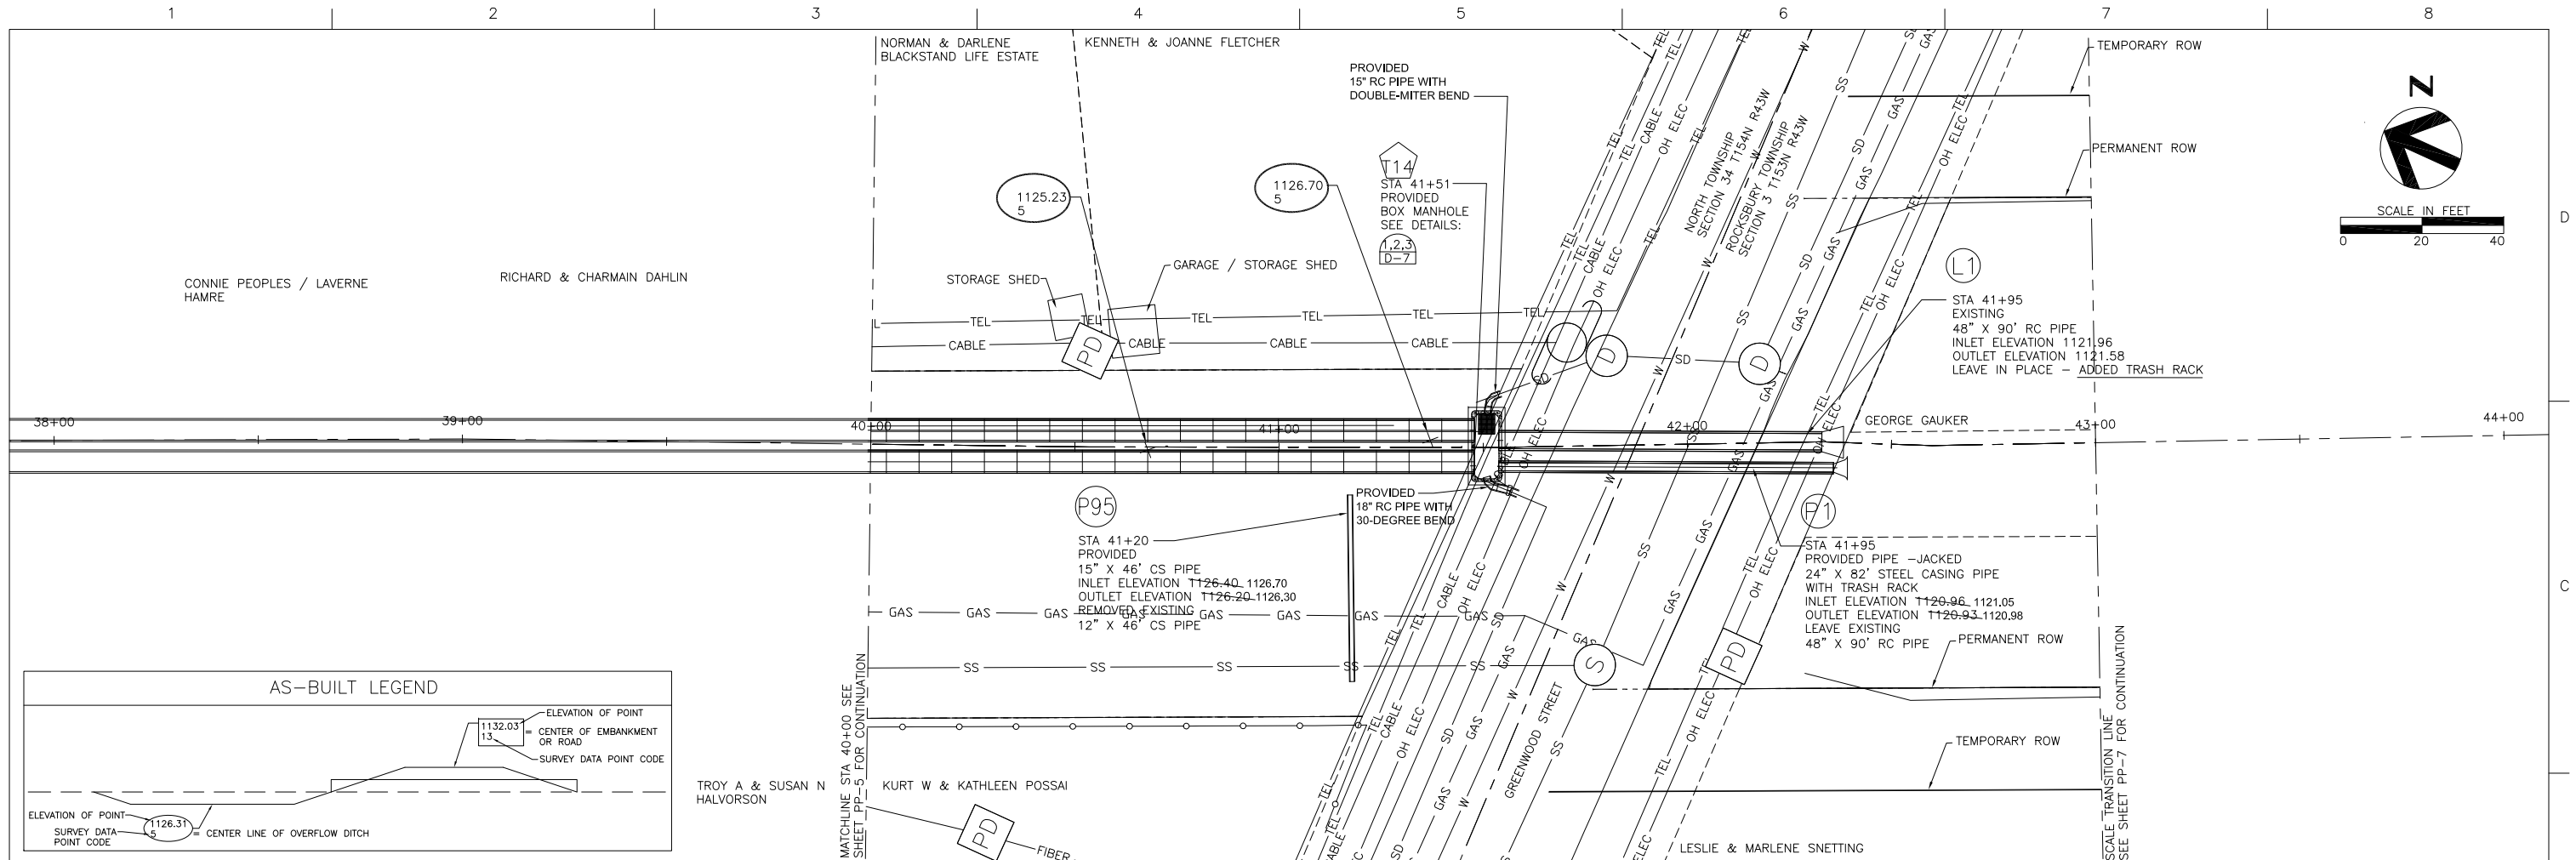

ISSUE	DATE	DESCRIPTION

PROJECT MANAGER	Nathan P. Dalager
DESIGNED	G. Hufnagle
DESIGNED	M. Peterson
CHECKED	R. Knott
CHECKED	M. Redington
DRAWN	
DRAWN	
PROJECT NUMBER	131515

I HEREBY CERTIFY THAT THIS PLAN, SPECIFICATION, OR REPORT WAS PREPARED BY ME OR UNDER MY DIRECT SUPERVISION AND THAT I AM A DULY REGISTERED PROFESSIONAL ENGINEER UNDER THE LAWS OF THE STATE OF MINNESOTA.

DATE 1/21/2013 REG. NO. 25309

Nathan P. Dalager


Nathan P. Dalager


Red Lake Watershed District



1000 PENNINGTON AVE.
THIEF RIVER FALLS, MN 56701
(218) 681-5800

THIEF RIVER FALLS FLOOD DAMAGE REDUCTION PROJECT AND IMPROVEMENT TO PENNINGTON COUNTY DITCH #1 (RLWD DITCH #14)


FILENAME		OOC-PP05-06.dwg	SHEET
RLWD DITCH #14 STORM SEWER PLAN AND PROFILE STA 40+00 TO 43+00 AS-BUILT - JANUARY 2013			PP-6

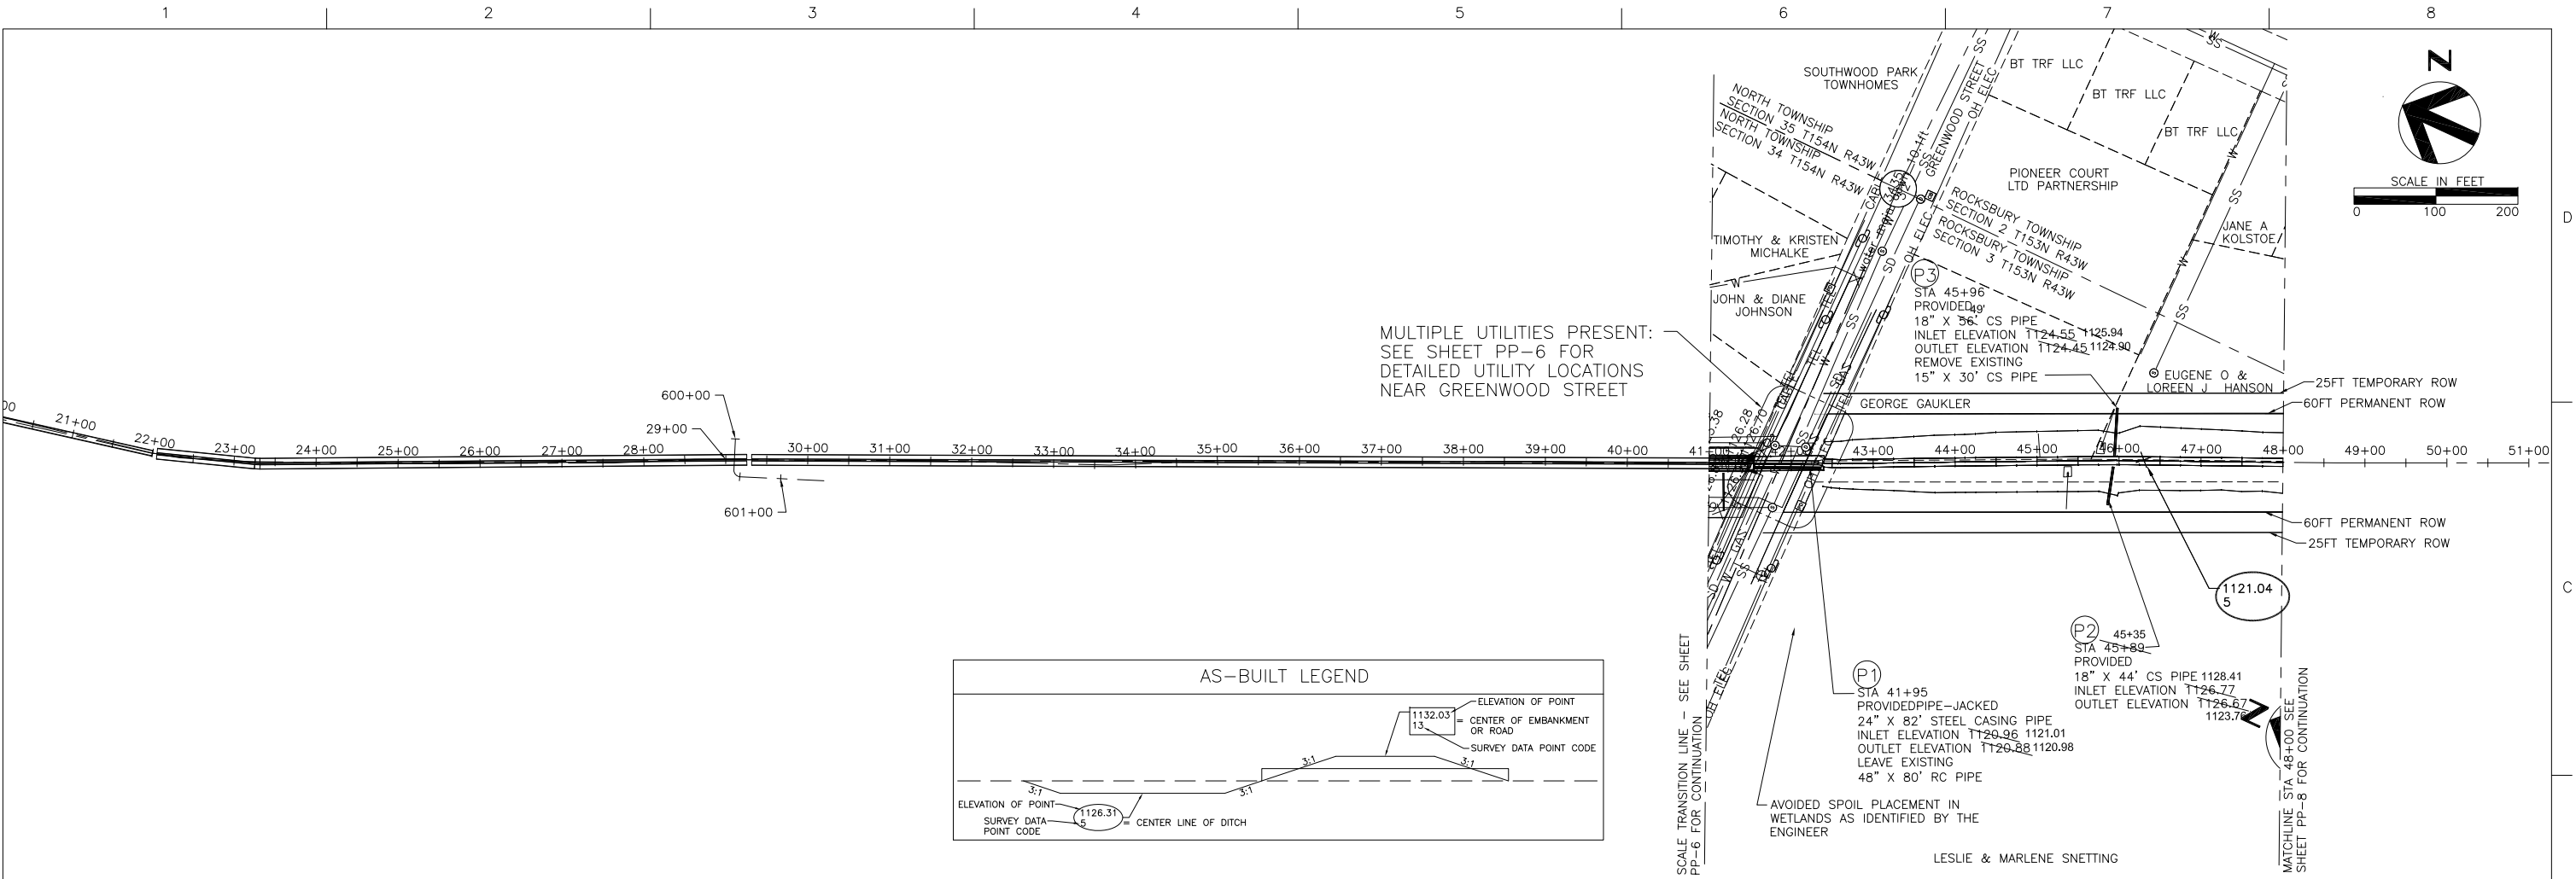

  HDR Engineering, Inc. 324 2nd St, E. Thief River Falls, MN 56701 (218) 681-6100				PROJECT MANAGER	Nathan P. Dalager	I HEREBY CERTIFY THAT THIS PLAN, SPECIFICATION, OR REPORT WAS PREPARED BY ME OR UNDER MY DIRECT SUPERVISION AND THAT I AM A DULY REGISTERED PROFESSIONAL ENGINEER UNDER THE LAWS OF THE STATE OF MINNESOTA. DATE 1/21/2013 REG. NO. 25309  Nathan P. Dalager	Red Lake Watershed District 1000 PENNINGTON AVE. THIEF RIVER FALLS, MN 56701 (218) 681-5800 THIEF RIVER FALLS FLOOD DAMAGE REDUCTION PROJECT AND IMPROVEMENT TO PENNINGTON COUNTY DITCH #1 (RLWD DITCH #14)	RLWD DITCH #14 PLAN AND PROFILE STA 41+00 TO 48+00 AS-BUILT - JANUARY 2013 0 1/2" 1" FILENAME 00C-PP01-02.dwg SHEET PP-7
				DESIGNED	G. Hufnagle			
				DESIGNED	M. Peterson			
				CHECKED	M. Redington			
				CHECKED				
				DRAWN				
			DRAWN					
ISSUE	DATE	DESCRIPTION	PROJECT NUMBER	131515				

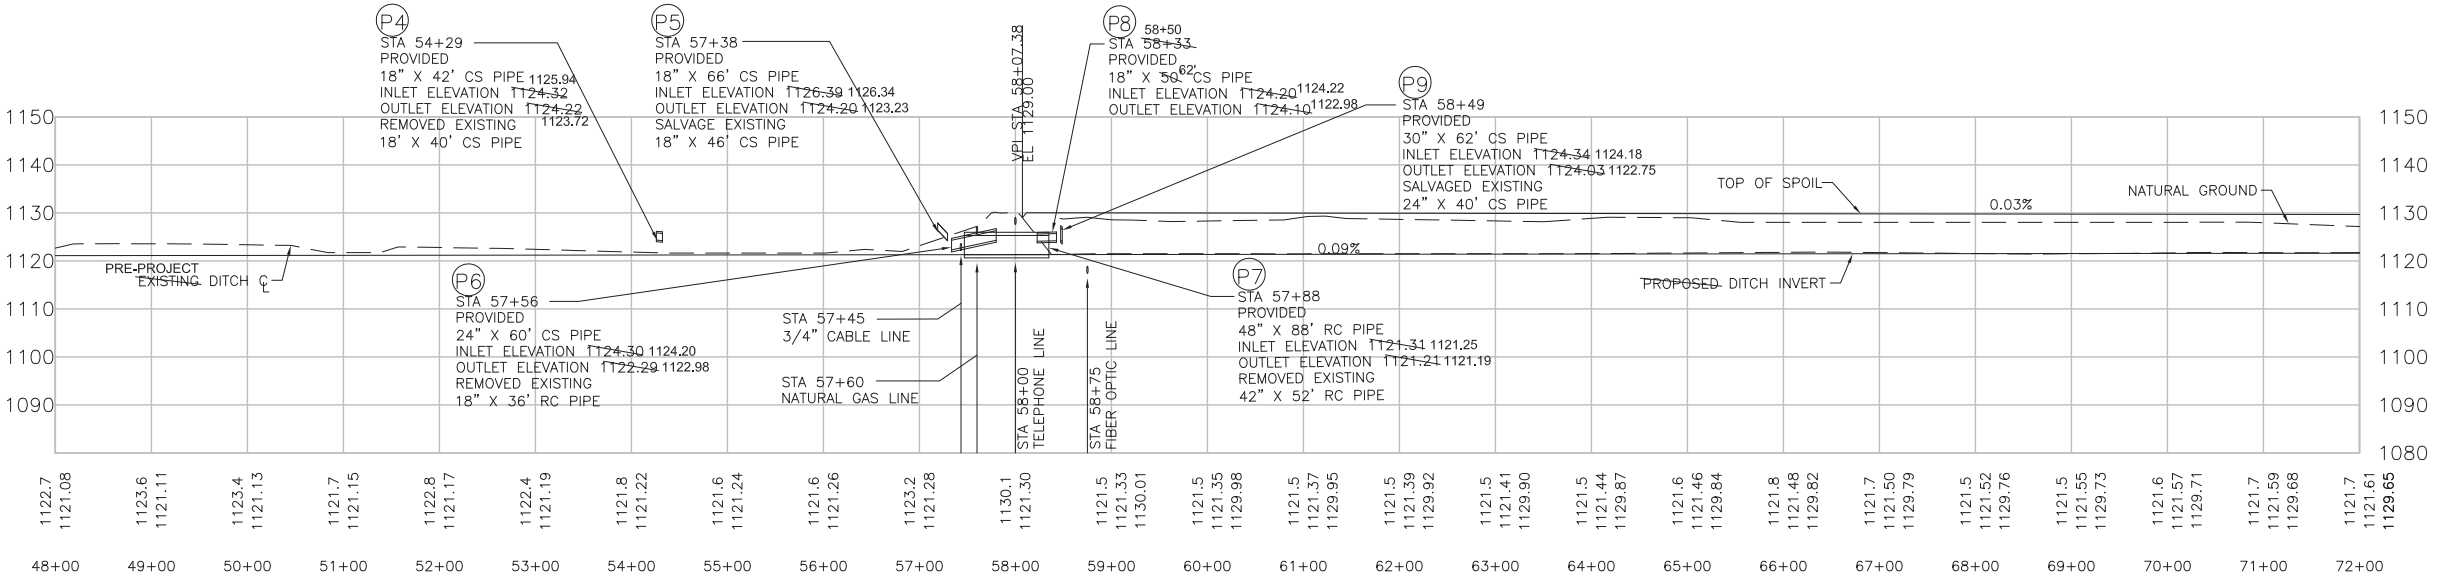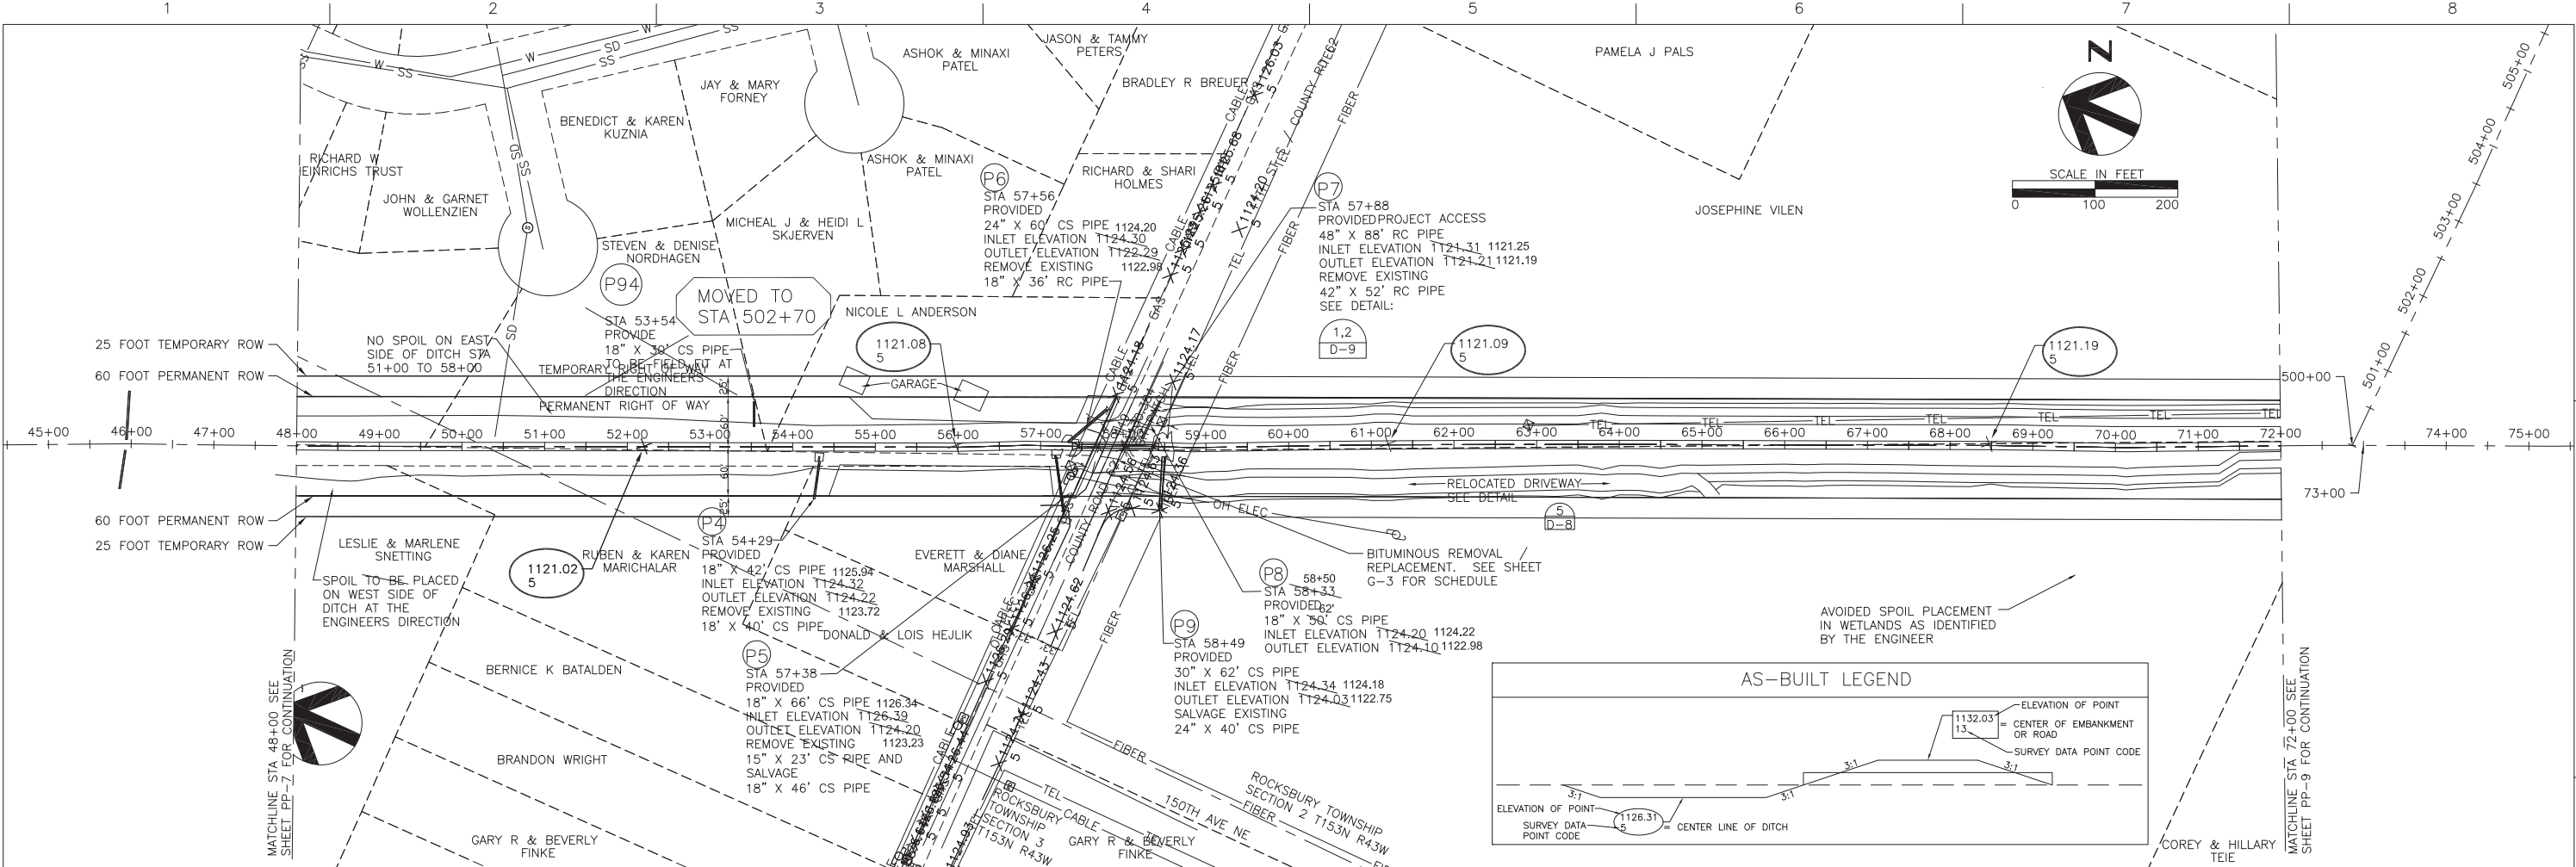

NOTE:
SEE UT-8 FOR UTILITY
COORDINATION AND
RELOCATION INSTRUCTIONS

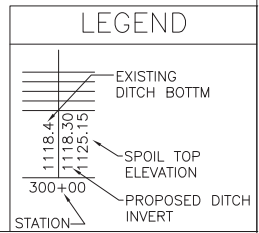

ISSUE	DATE	DESCRIPTION

PROJECT MANAGER	Nathan P. Dalager
DESIGNED	R. Knott
DESIGNED	G. Hufnagle
CHECKED	M. Redington
CHECKED	
DRAWN	
DRAWN	
PROJECT NUMBER	131515

I HEREBY CERTIFY THAT THIS PLAN, SPECIFICATION, OR REPORT WAS PREPARED BY ME OR UNDER MY DIRECT SUPERVISION AND THAT I AM A DULY REGISTERED PROFESSIONAL ENGINEER UNDER THE LAWS OF THE STATE OF MINNESOTA.

DATE 1/21/2013 REG. NO. 25309

Nathan P. Dalager

Nathan P. Dalager


Red Lake Watershed District



1000 PENNINGTON AVE.
THIEF RIVER FALLS, MN 56701 (218) 681-5800

THIEF RIVER FALLS FLOOD DAMAGE REDUCTION PROJECT AND IMPROVEMENT TO PENNINGTON COUNTY DITCH #1 (RLWD DITCH #14)



FILENAME		OOC-PP01-03.dwg	SHEET	
			PP-8	

 **RLWD DITCH #14
PLAN AND PROFILE
STA 48+00 TO 72+00
AS-BUILT - JANUARY 2013**



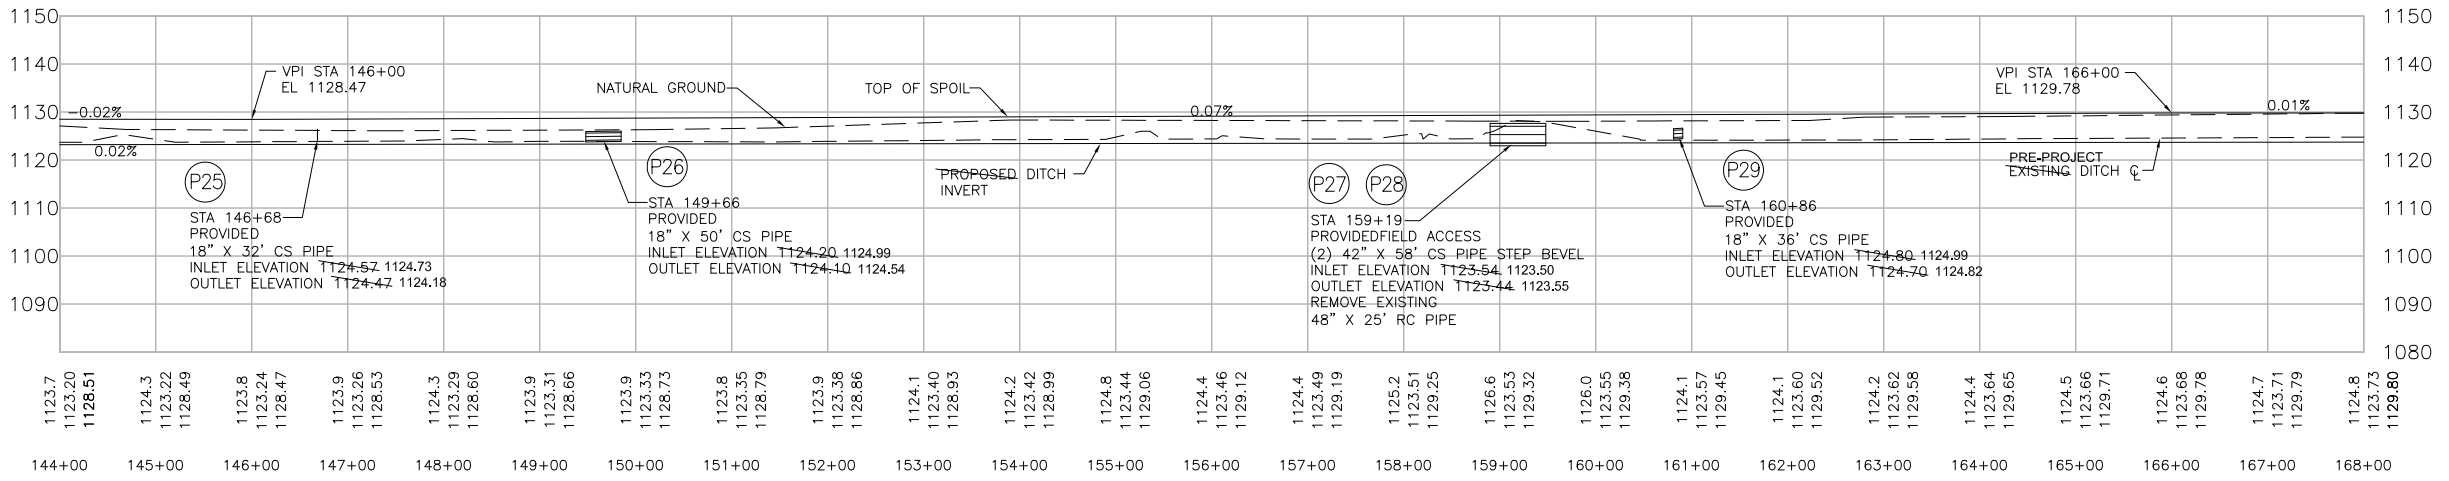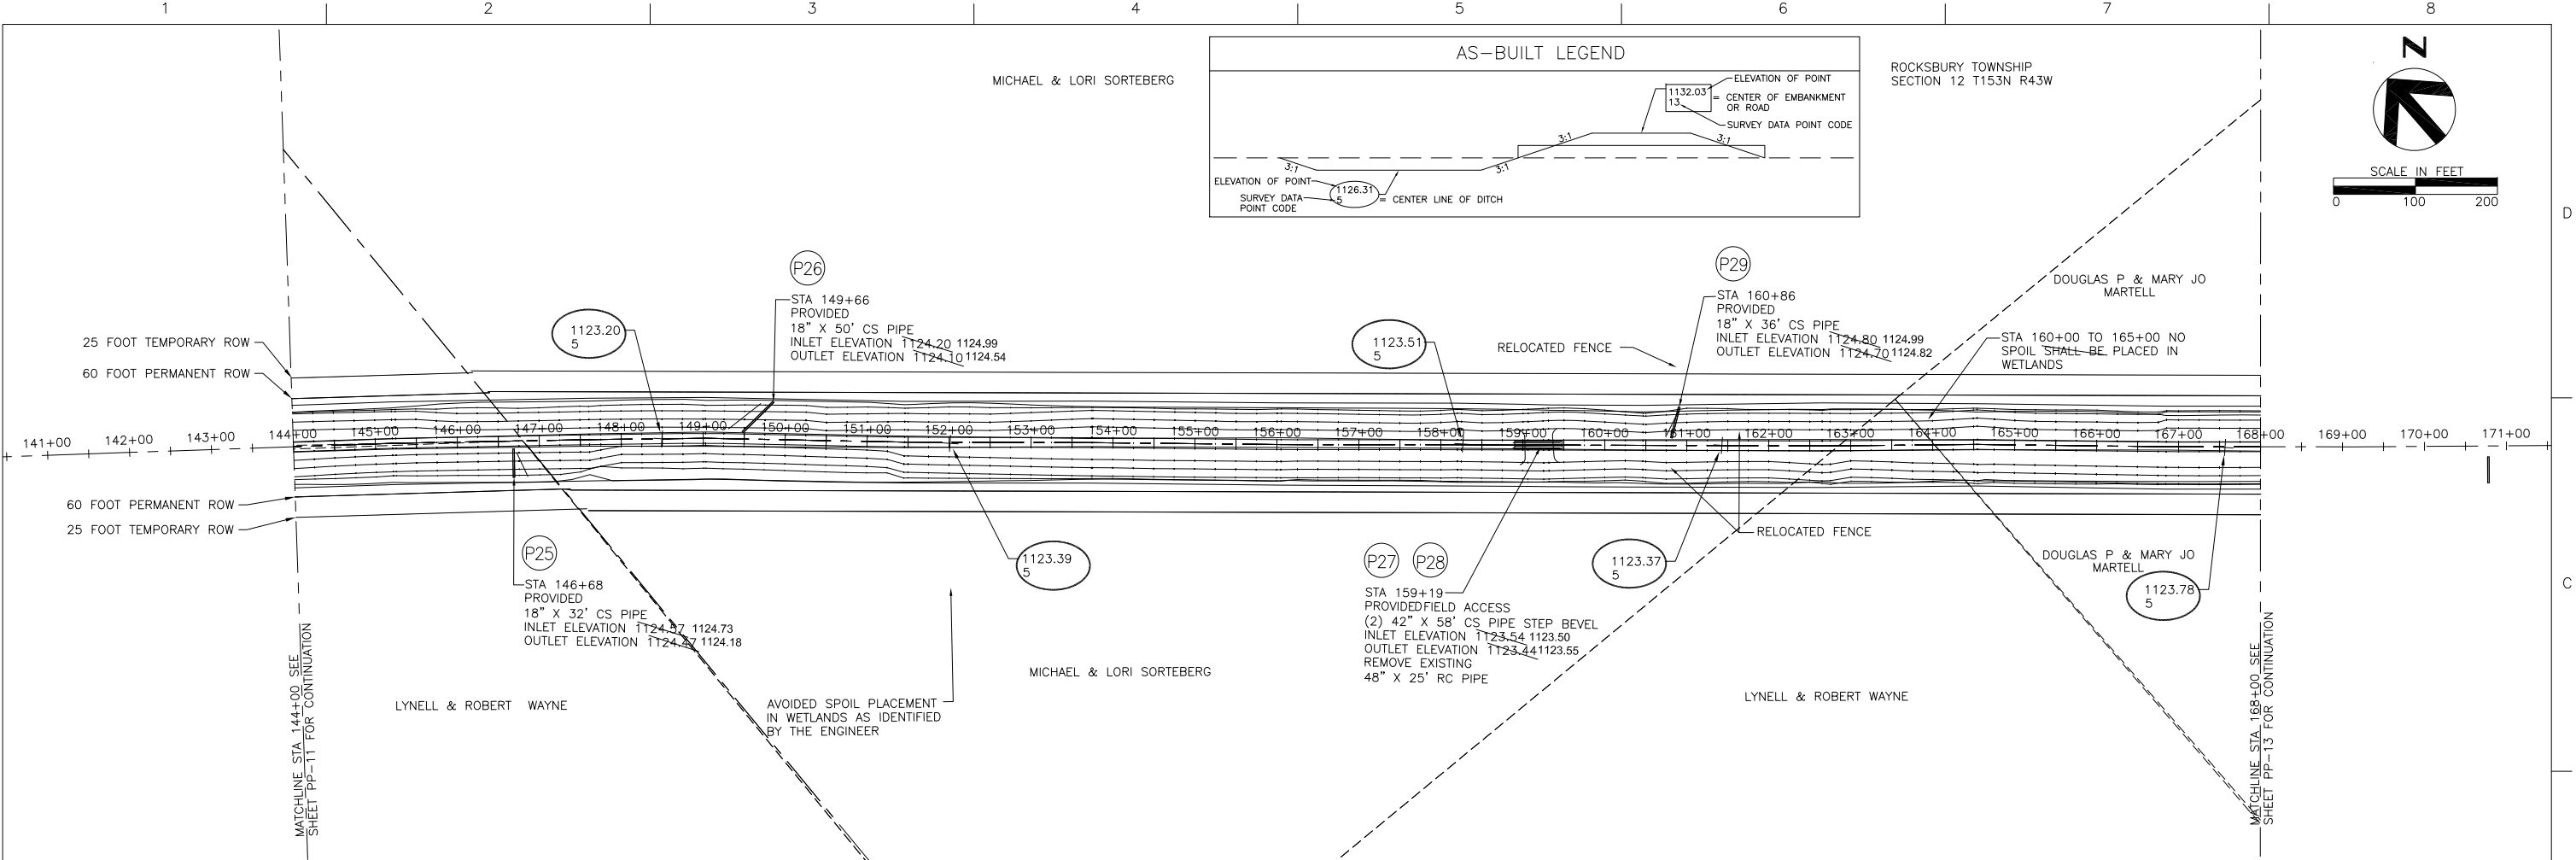

NOTE:
SEE UT-12 FOR UTILITY
COORDINATION AND
RELOCATION INSTRUCTIONS

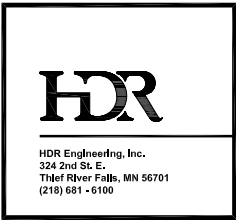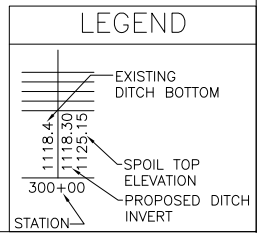

ISSUE	DATE	DESCRIPTION

PROJECT MANAGER	Nathan P. Dalager
DESIGNED	G. Hufnagle
DESIGNED	R. Knott
CHECKED	M. Redington
CHECKED	
DRAWN	
DRAWN	
PROJECT NUMBER	131515

I HEREBY CERTIFY THAT THIS PLAN,
SPECIFICATION, OR REPORT WAS
PREPARED BY ME OR UNDER MY
DIRECT SUPERVISION AND THAT I AM
A DULY REGISTERED PROFESSIONAL
ENGINEER UNDER THE LAWS OF THE
STATE OF MINNESOTA.

DATE 1/21/2013 REG. NO. 25309

Nathan P. Dalager

Nathan P. Dalager

Red Lake
Watershed District

1000 PENNINGTON AVE.
THIEF RIVER FALLS, MN
56701 (218) 681-5800



THIEF RIVER FALLS FLOOD DAMAGE REDUCTION
PROJECT AND IMPROVEMENT TO PENNINGTON
COUNTY DITCH #1 (RLWD DITCH #14)

RLWD DITCH #14
PLAN AND PROFILE
STA 144+00 TO 168+00
AS-BUILT - JANUARY 2013

0 1/2" 1"

FILENAME 00C-PP01-07.dwg

SHEET PP-12

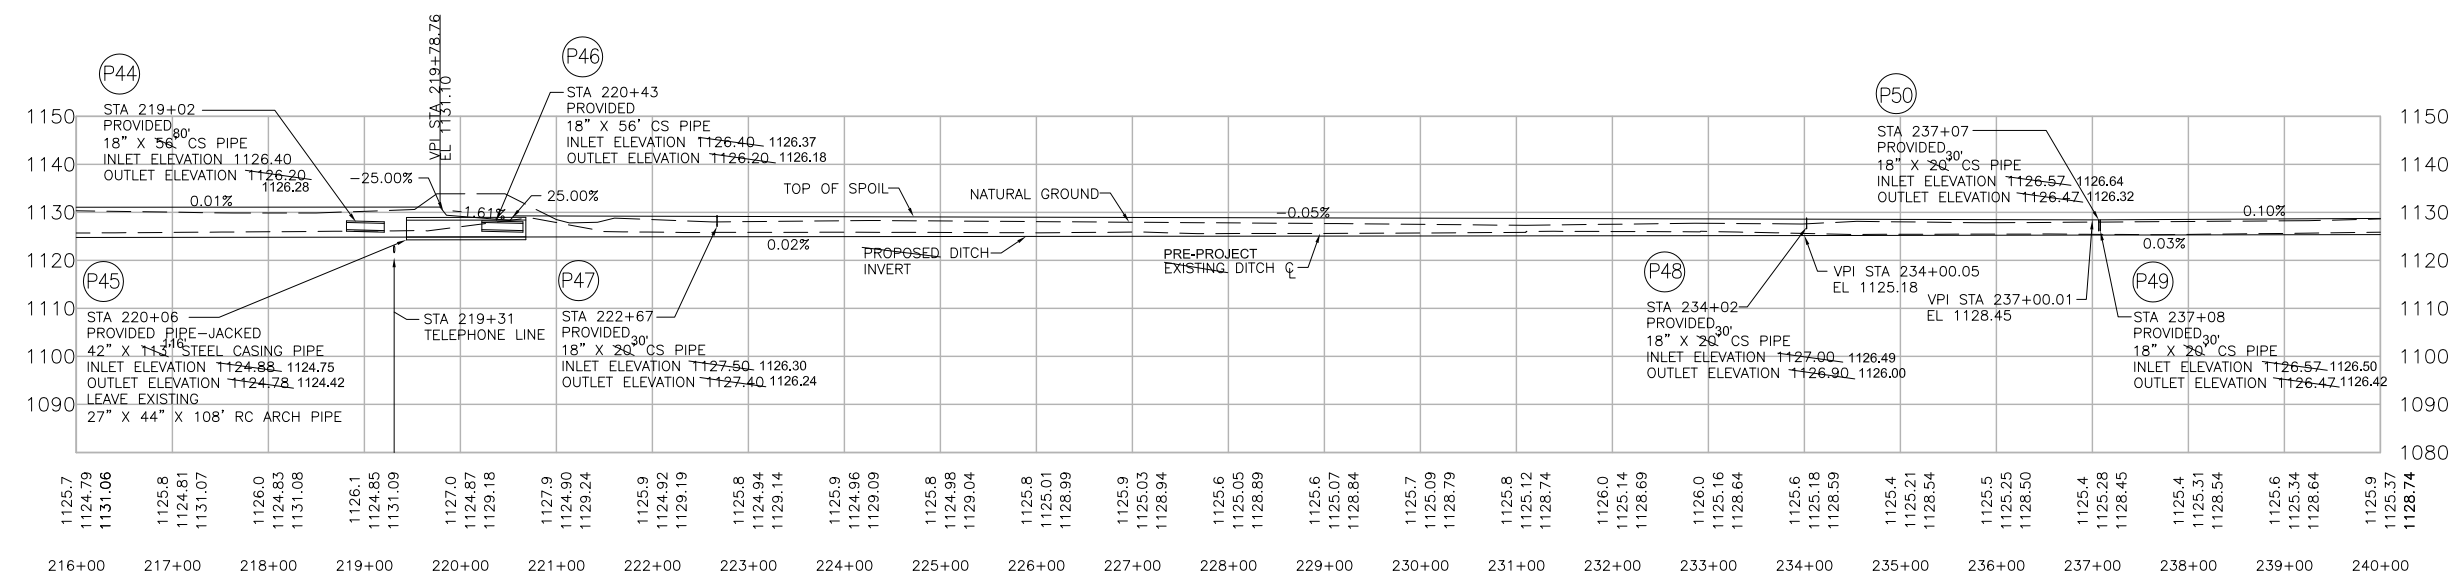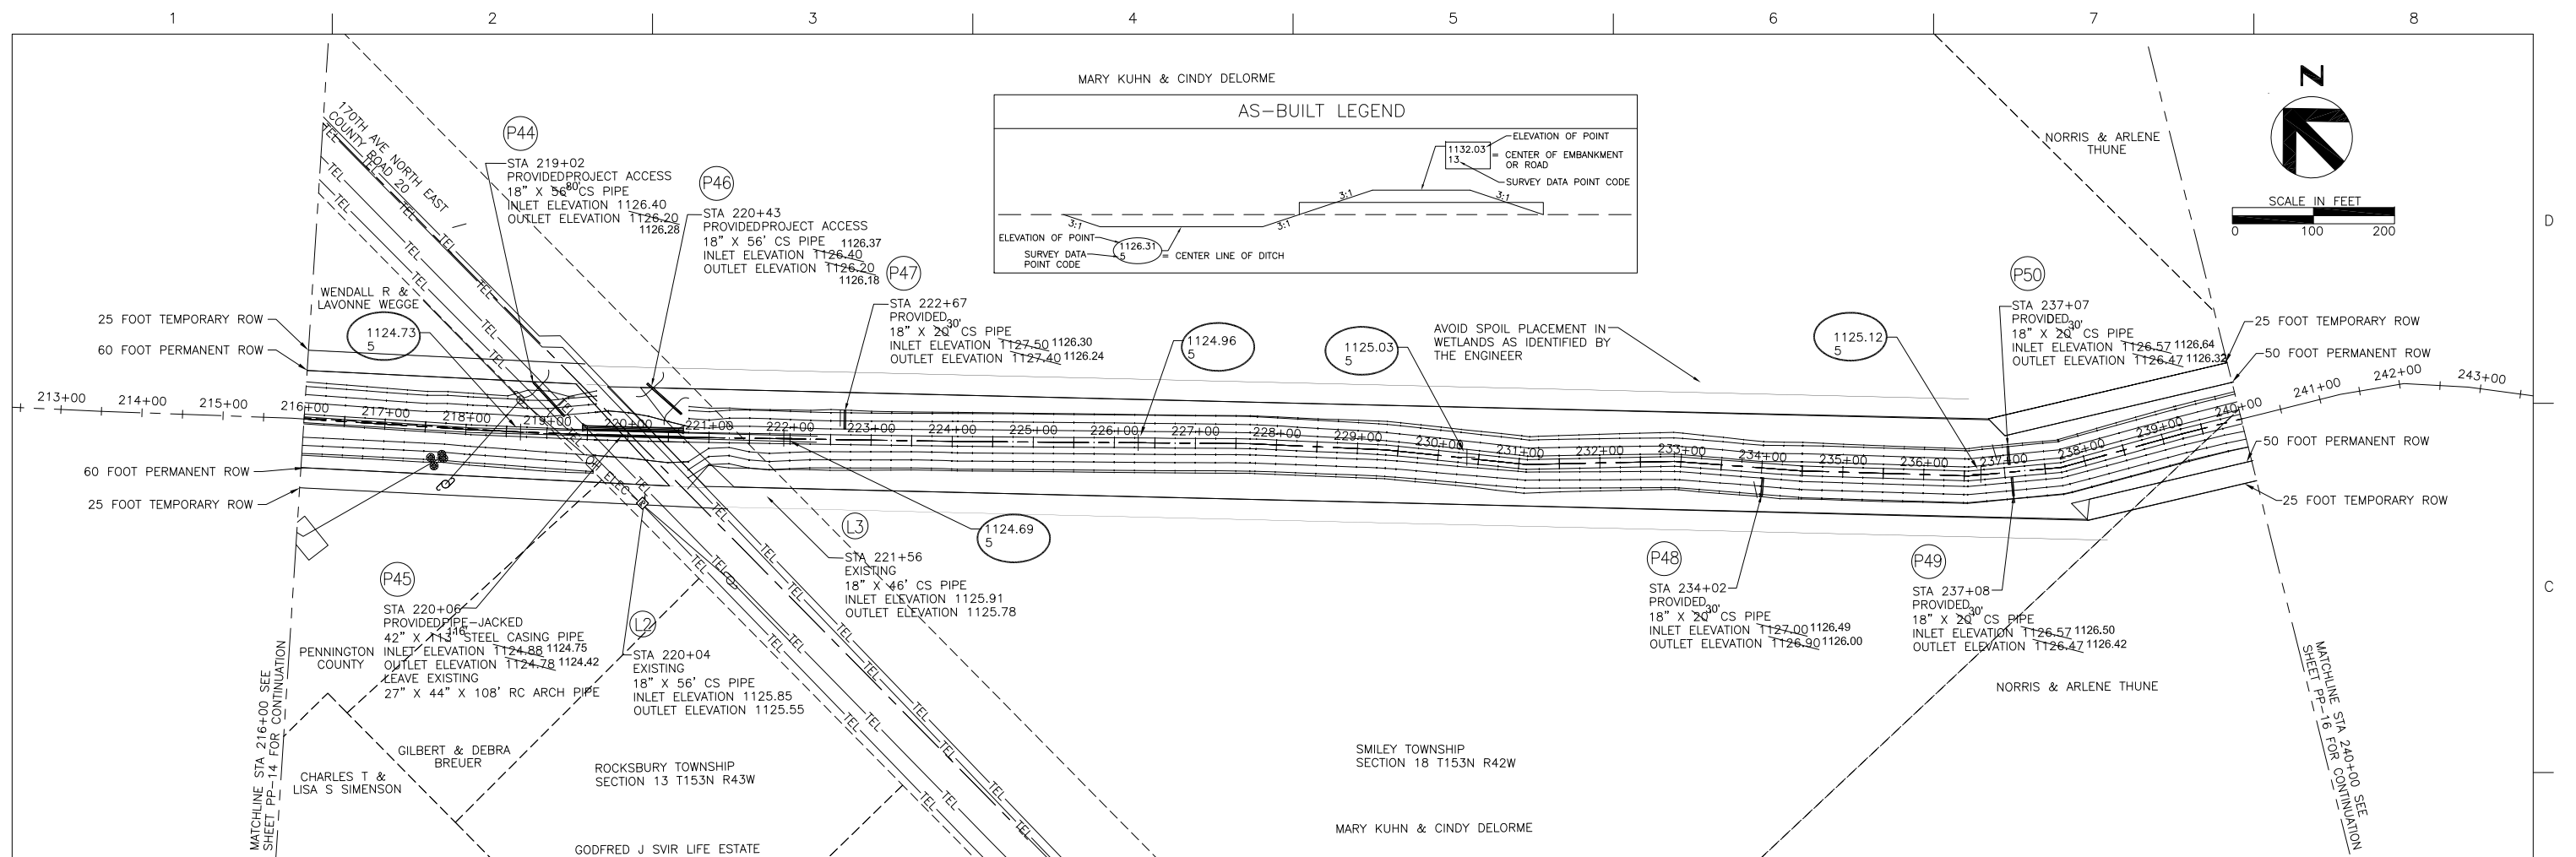

NOTE:
SEE UT-15 FOR UTILITY
COORDINATION AND
RELOCATION INSTRUCTIONS





PROJECT MANAGER	Nathan P. Dalager
DESIGNED	G. Hufnagle
DESIGNED	R. Knott
CHECKED	M. Redington
CHECKED	
DRAWN	
DRAWN	
PROJECT NUMBER	131515


I HEREBY CERTIFY THAT THIS PLAN, SPECIFICATION, OR REPORT WAS PREPARED BY ME OR UNDER MY DIRECT SUPERVISION AND THAT I AM A DULY REGISTERED PROFESSIONAL ENGINEER UNDER THE LAWS OF THE STATE OF MINNESOTA.




Red Lake Watershed District 1000 PENNINGTON AVE.
THIEF RIVER FALLS, MN 56701 (218) 681-5800

THIEF RIVER FALLS FLOOD DAMAGE REDUCTION
PROJECT AND IMPROVEMENT TO PENNINGTON
COUNTY DITCH #1 (RLWD DITCH #14)

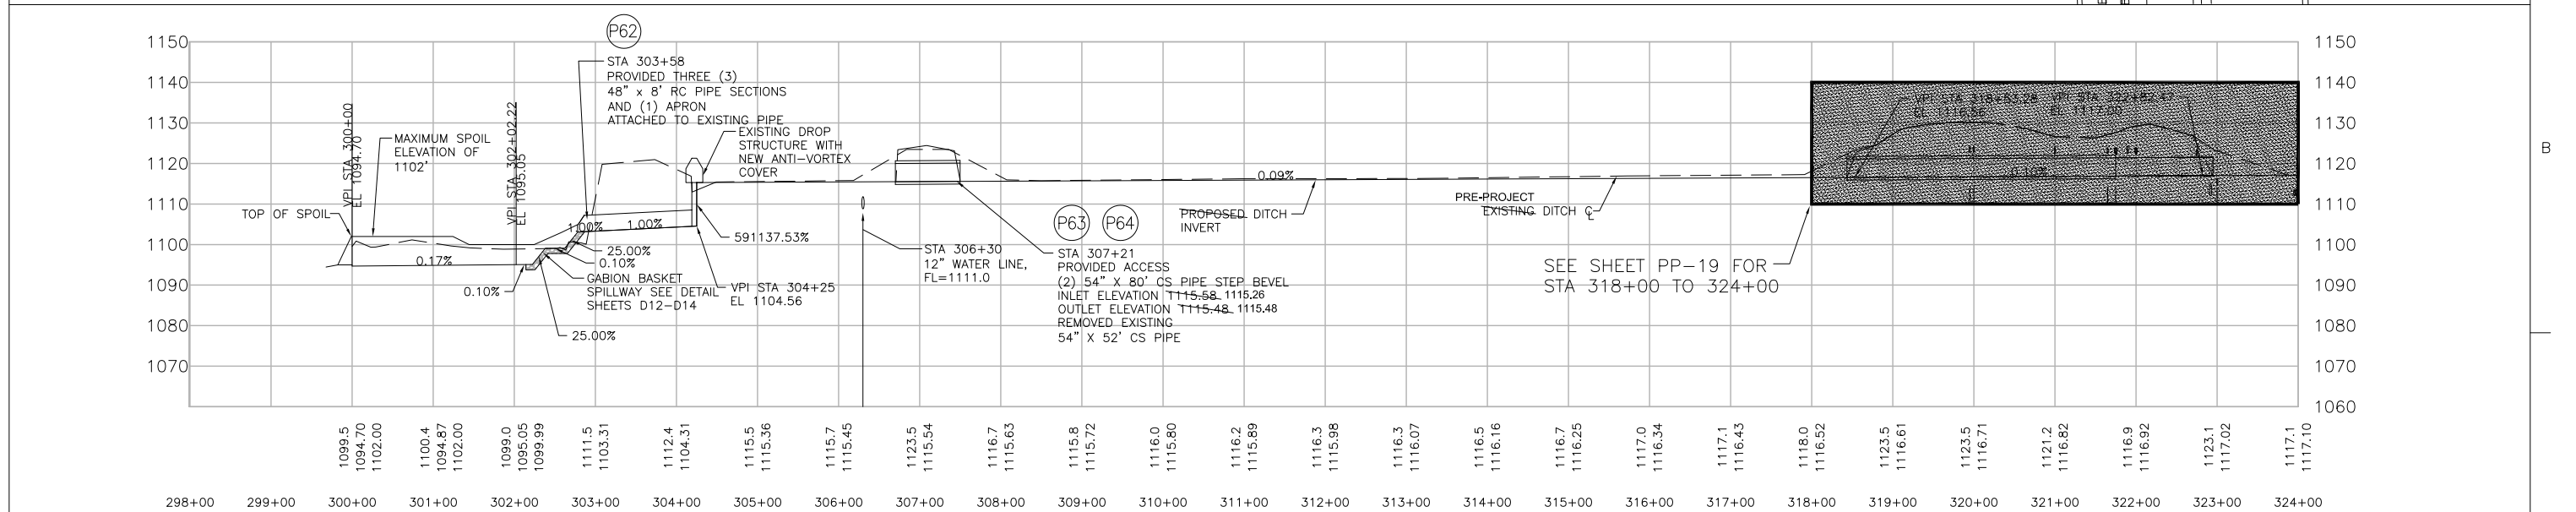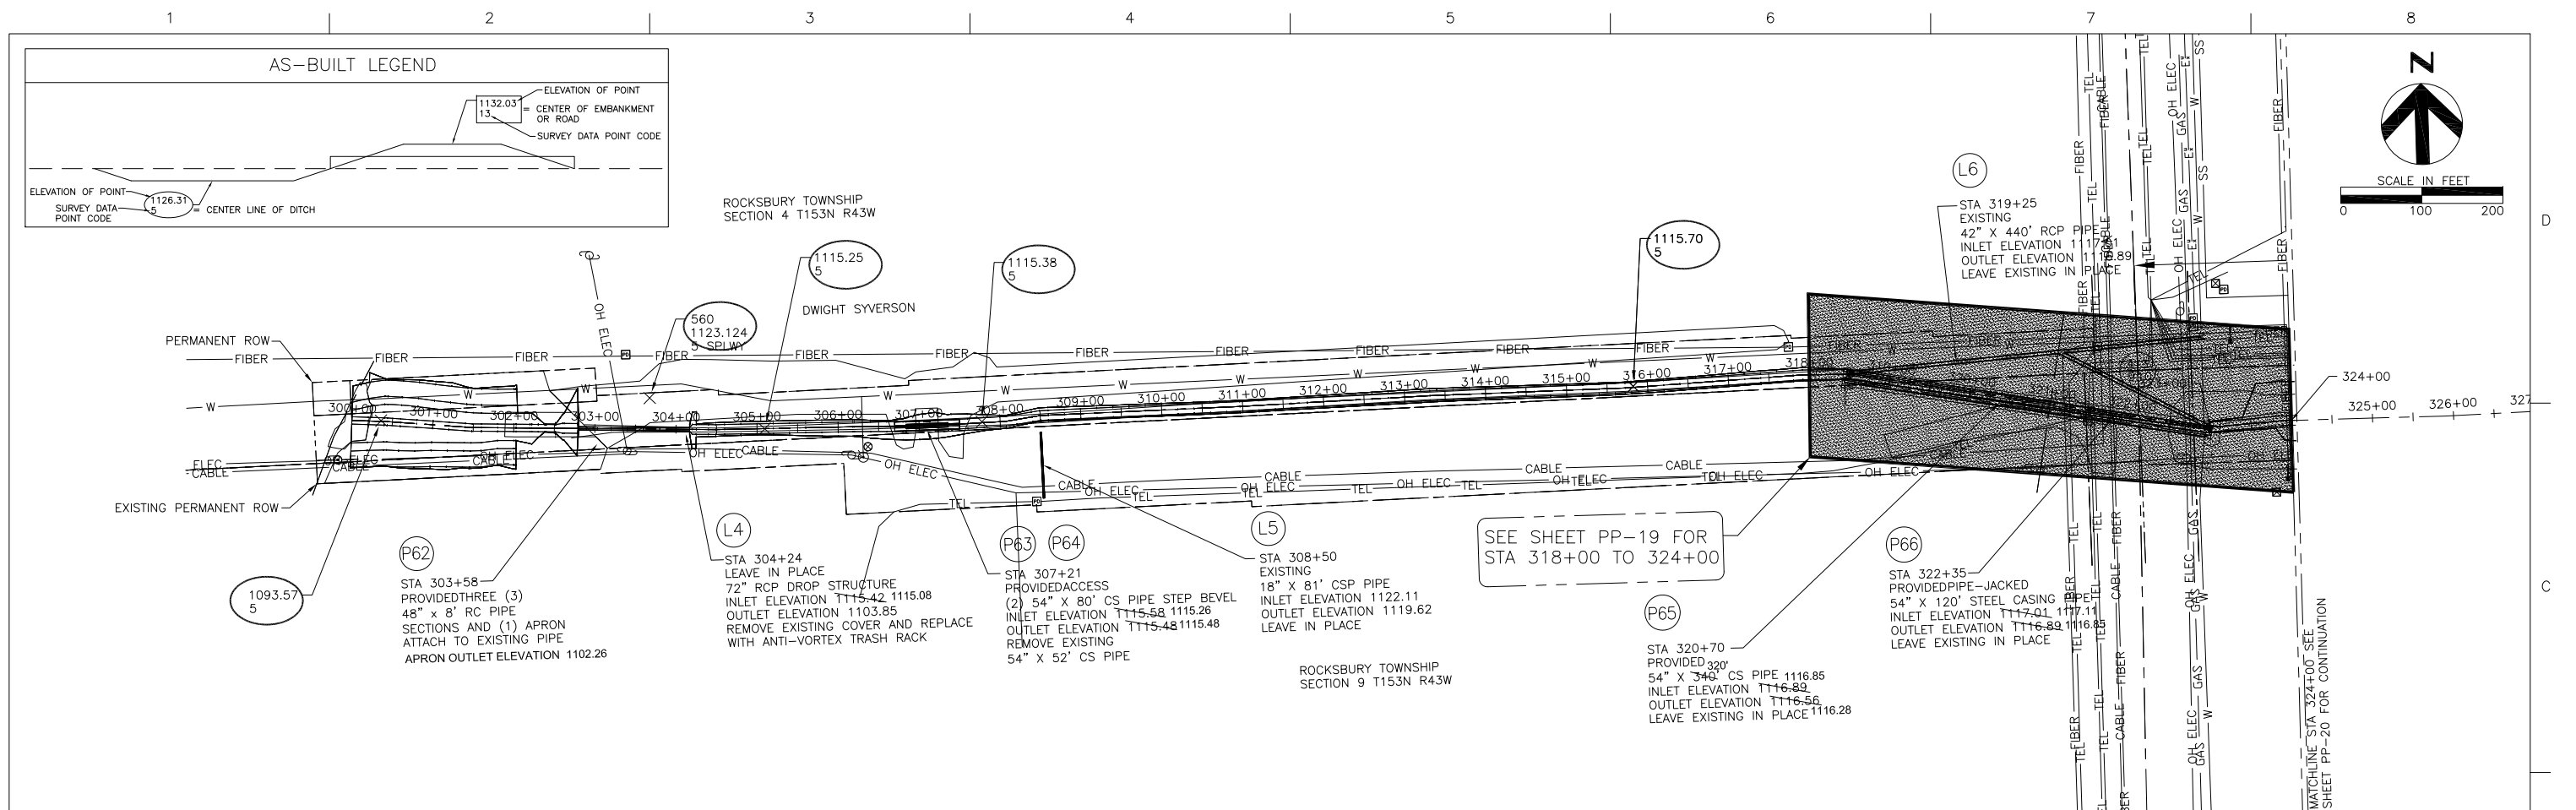

CHALLENGER DITCH STATIONING REFERENCE	
COUNTY DITCH 1 DIVERSION STATION (2011)	RLWD PROJECT 122 CHALLENGER DITCH STATION (1997)
300+00	78+00
310+00	87+90
320+00	97+90
330+00	107+76
340+00	117+80
350+25	128+07 (END OF ALIGNMENT)

  HDR Engineering, Inc. 324 2nd St. E. Thief River Falls, MN 56701 (218) 681-6100				PROJECT MANAGER	Nathan P. Dalager	I HEREBY CERTIFY THAT THIS PLAN, SPECIFICATION, OR REPORT WAS PREPARED BY ME OR UNDER MY DIRECT SUPERVISION AND THAT I AM A DULY REGISTERED PROFESSIONAL ENGINEER UNDER THE LAWS OF THE STATE OF MINNESOTA. DATE 1/21/2013 REG. NO. 25309  Nathan P. Dalager	Red Lake Watershed District THIEF RIVER FALLS FLOOD DAMAGE REDUCTION PROJECT AND IMPROVEMENT TO PENNINGTON COUNTY DITCH #1 (RLWD DITCH #14)	1000 PENNINGTON AVE. THIEF RIVER FALLS, MN 56701 (218) 681-5800	TRF FLOOD DAMAGE REDUCTION PROJECT DIVERSION PLAN AND PROFILE STA 300+00 TO 324+00 AS-BUILT - JANUARY 2013		FILENAME OOC-PP03-01.dwg	SHEET PP-18
				DESIGNED	R.Knott							
				DESIGNED	G. Hufnagle							
				CHECKED	M. Redington							
				CHECKED								
				DRAWN								
				DRAWN								
	ISSUE	DATE	DESCRIPTION	PROJECT NUMBER	151818							

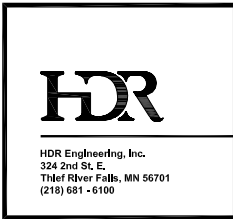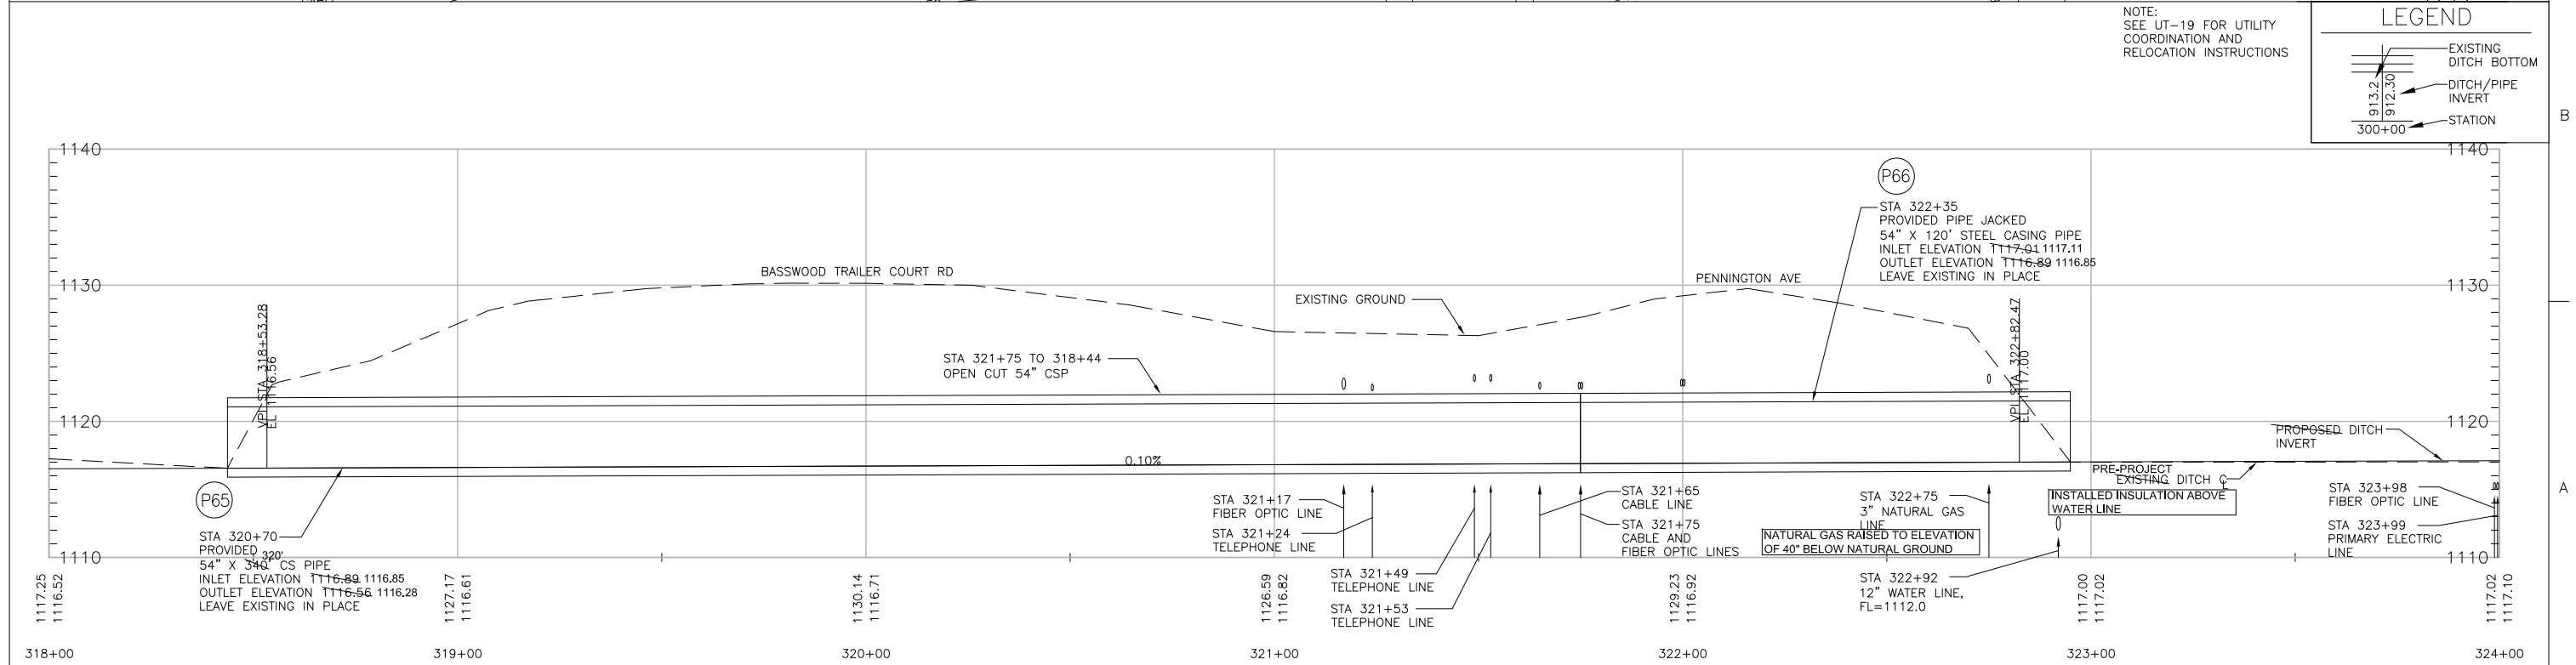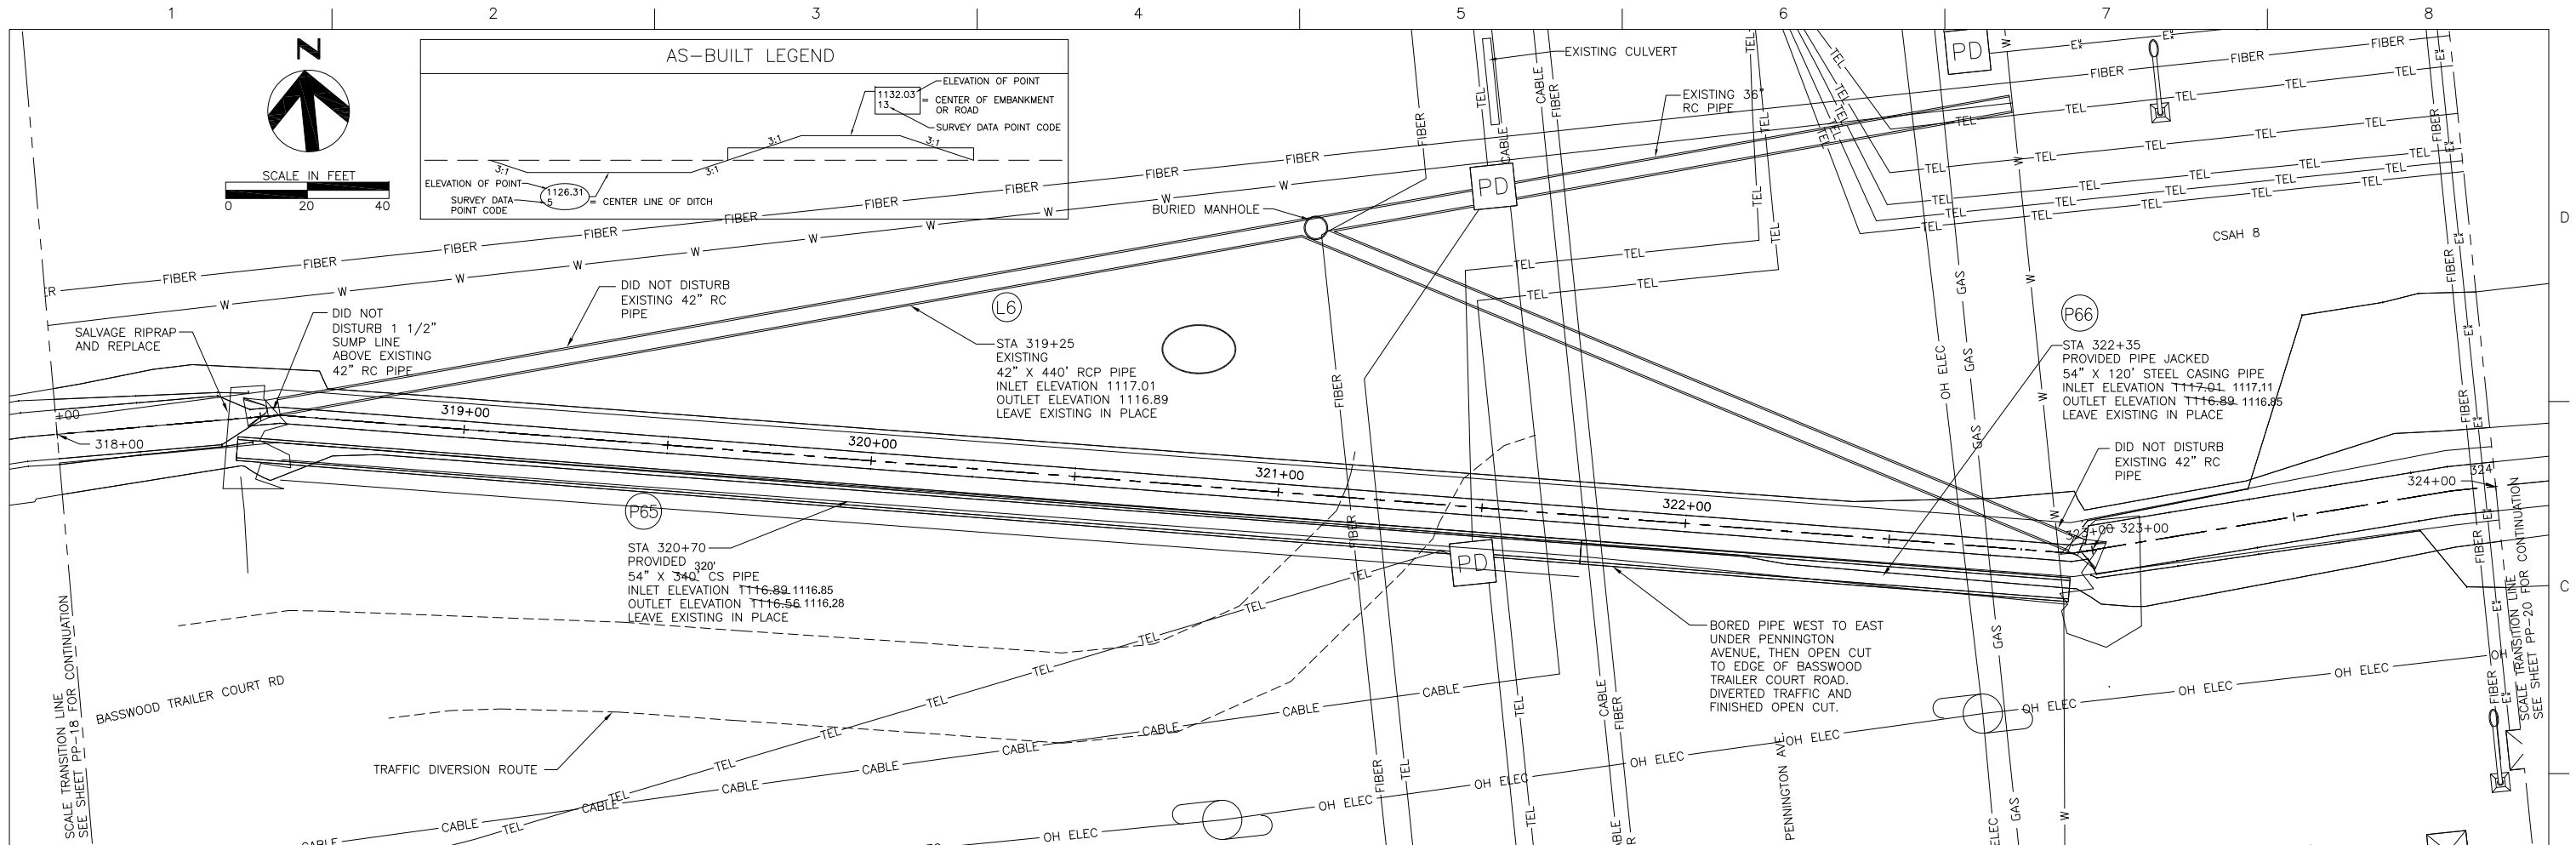

ISSUE	DATE	DESCRIPTION

PROJECT MANAGER	Nathan P. Dalager
DESIGNED	R. Knott
DESIGNED	M. Peterson
CHECKED	M. Redington
CHECKED	
DRAWN	
DRAWN	
PROJECT NUMBER	131515

I HEREBY CERTIFY THAT THIS PLAN, SPECIFICATION, OR REPORT WAS PREPARED BY ME OR UNDER MY DIRECT SUPERVISION AND THAT I AM A DULY REGISTERED PROFESSIONAL ENGINEER UNDER THE LAWS OF THE STATE OF MINNESOTA.

DATE 1/21/2013 REG. NO. 25309

Nathan P. Dalager

Nathan P. Dalager

Red Lake Watershed District



1000 PENNINGTON AVE.
THIEF RIVER FALLS, MN 56701
(218) 681-5800

THIEF RIVER FALLS FLOOD DAMAGE REDUCTION PROJECT AND IMPROVEMENT TO PENNINGTON COUNTY DITCH #1 (RLWD DITCH #14)


**TRF FLOOD DAMAGE REDUCTION PROJECT
DIVERSION PLAN AND PROFILE
STA 318+00 TO 324+00
AS-BUILT - JANUARY 2013**

0 1/2" 1"

FILENAME OOC-PP06-01.dwg SHEET PP-19

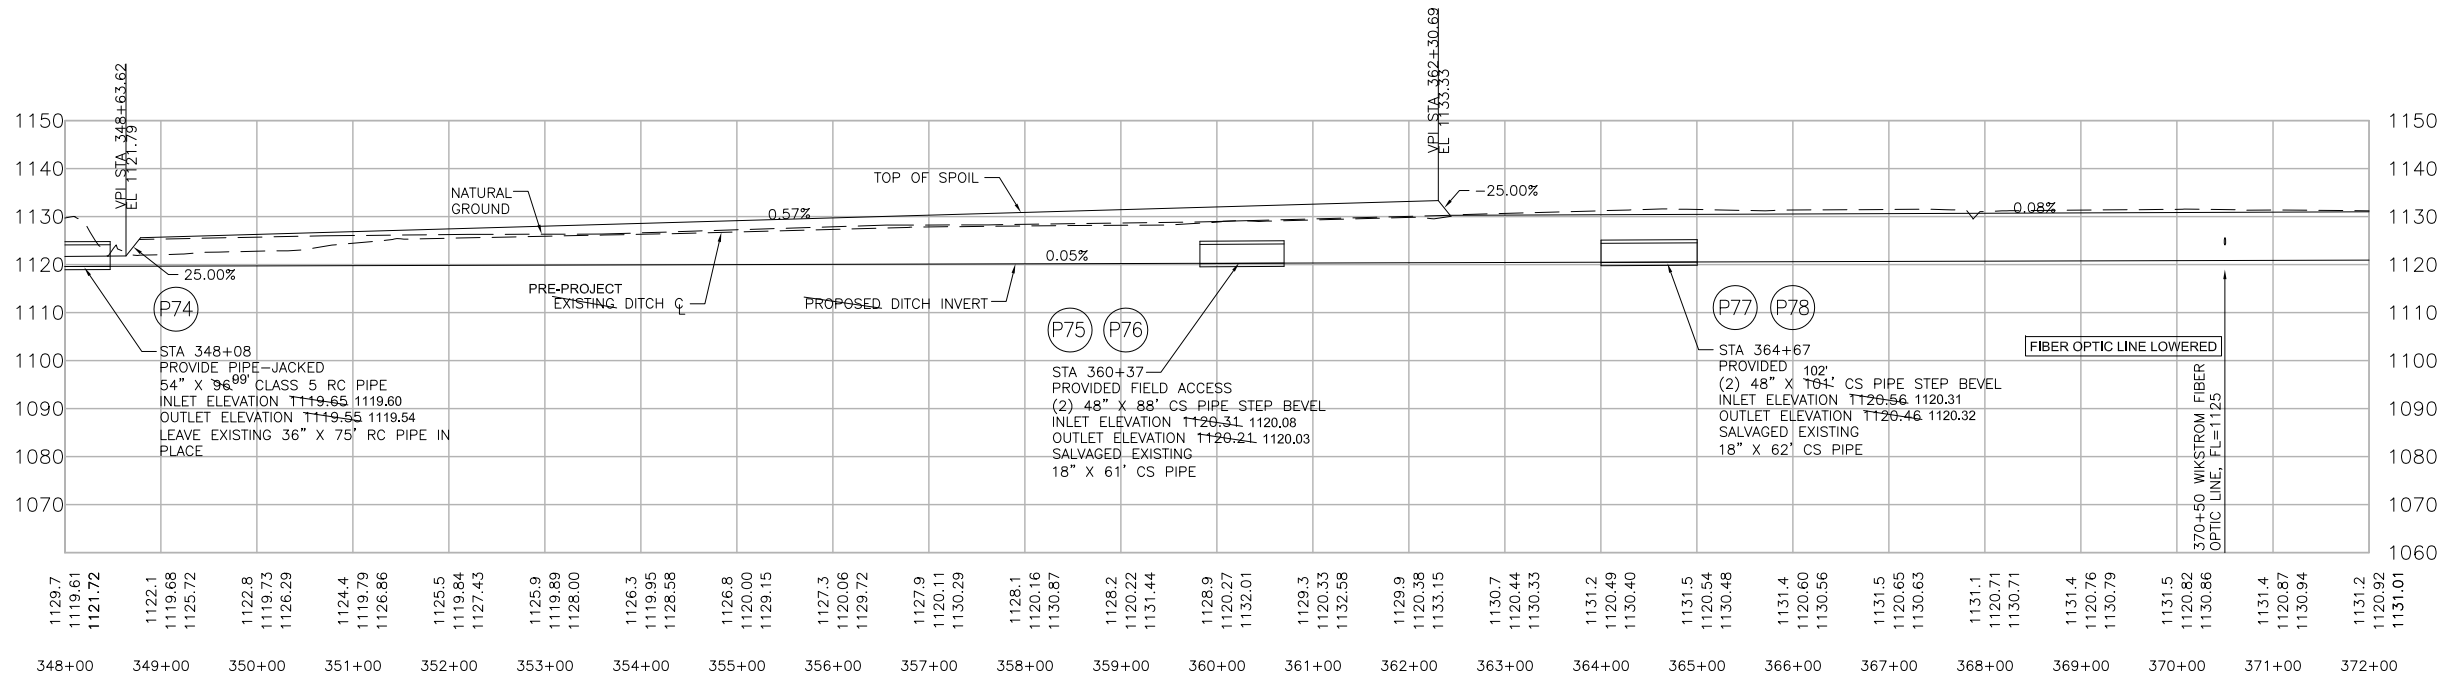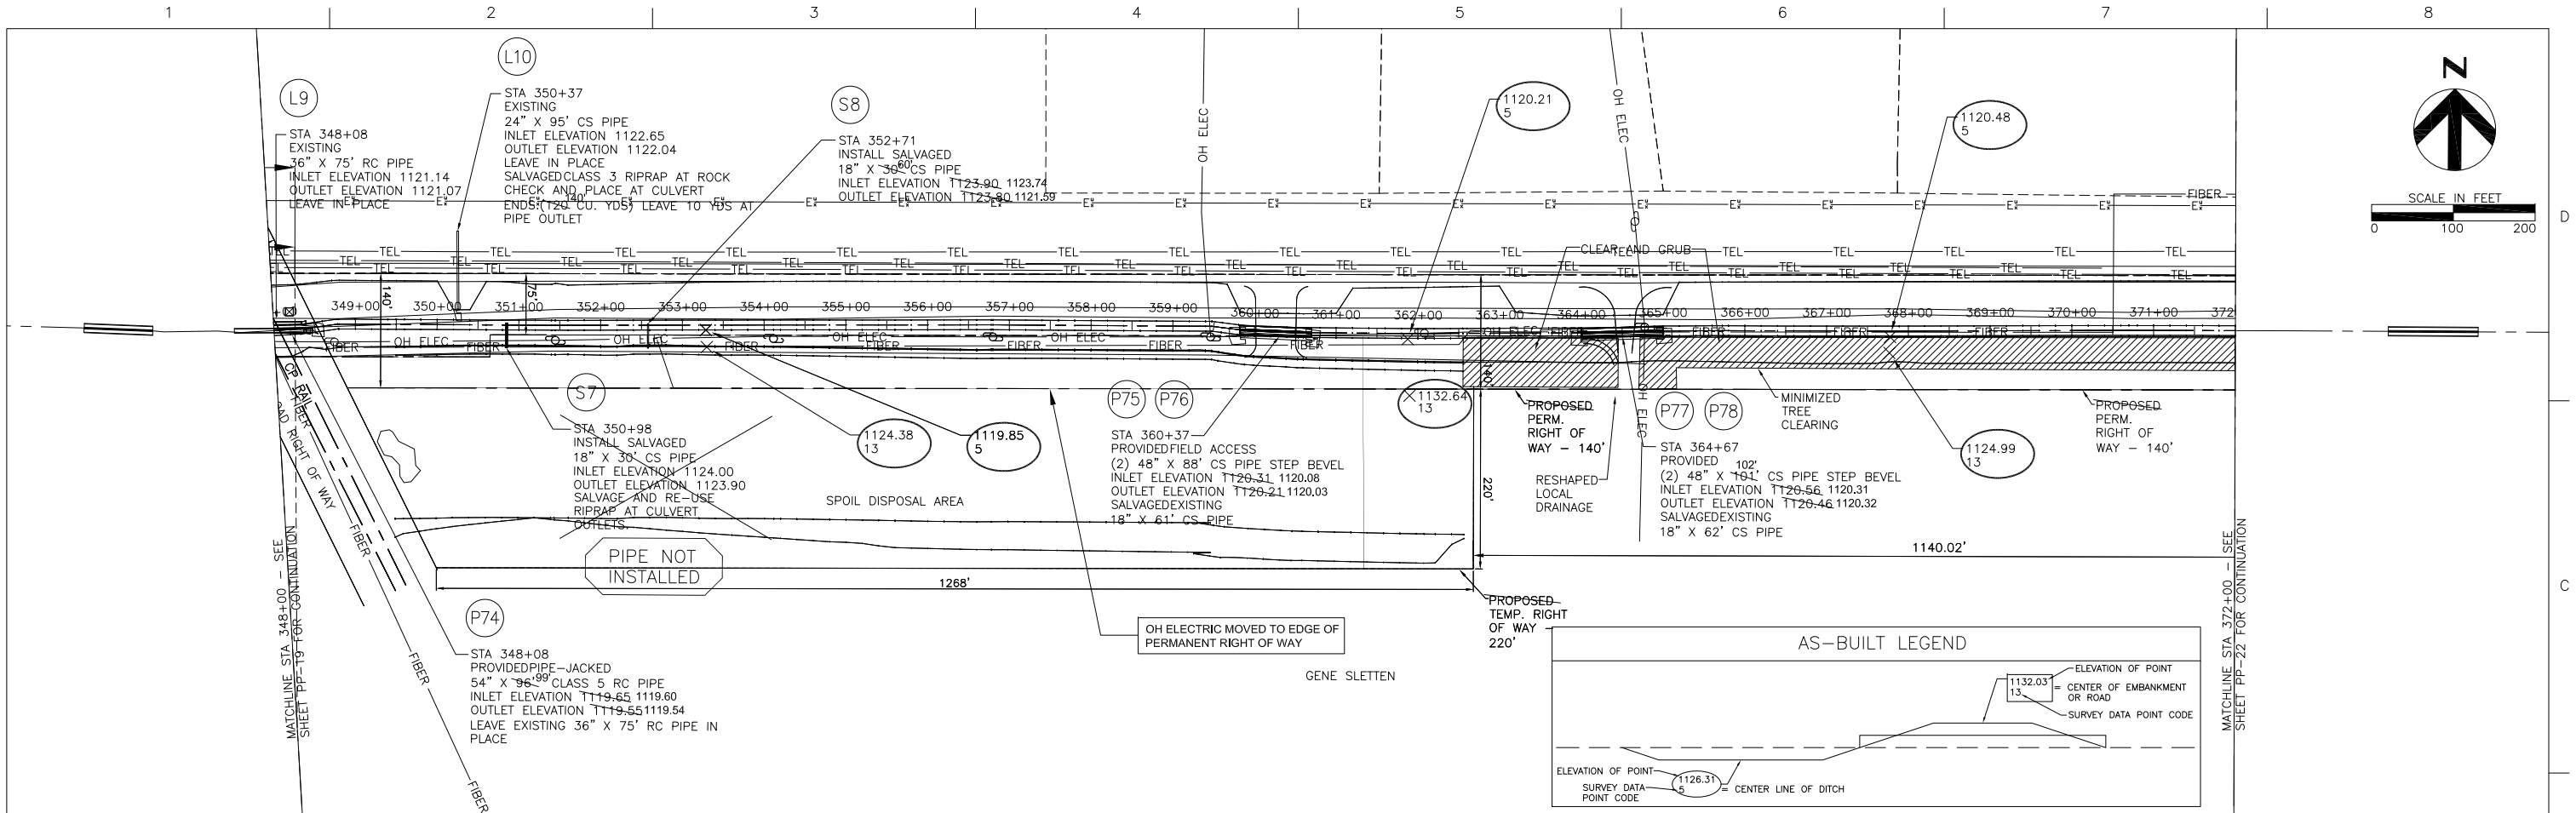

NOTE:
SEE UT-21 FOR UTILITY
COORDINATION AND
RELOCATION INSTRUCTIONS

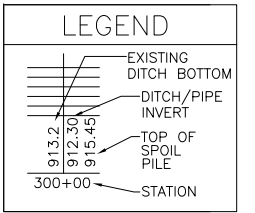

ISSUE	DATE	DESCRIPTION

PROJECT MANAGER	Nathan P. Dalager
DESIGNED	R. Knott
DESIGNED	G. Hufnagle
CHECKED	M. Redington
CHECKED	
DRAWN	
DRAWN	
PROJECT NUMBER	151818

I HEREBY CERTIFY THAT THIS PLAN, SPECIFICATION, OR REPORT WAS PREPARED BY ME OR UNDER MY DIRECT SUPERVISION AND THAT I AM A DULY REGISTERED PROFESSIONAL ENGINEER UNDER THE LAWS OF THE STATE OF MINNESOTA.

DATE 1/21/2013 REG. NO. 25309

Nathan P. Dalager

Nathan P. Dalager

Red Lake Watershed District

THIEF RIVER FALLS FLOOD DAMAGE REDUCTION PROJECT AND IMPROVEMENT TO PENNINGTON COUNTY DITCH #1 (RLWD DITCH #14)




1000 PENNINGTON AVE.
THIEF RIVER FALLS, MN
56701 (218) 681-5800

TRF FLOOD DAMAGE REDUCTION PROJECT
DIVERSION PLAN AND PROFILE
STA. 348+00 TO 372+00
AS-BUILT - JANUARY 2013


0 1/2" 1"

FILENAME 00C-PP03-03.dwg

SHEET PP-21

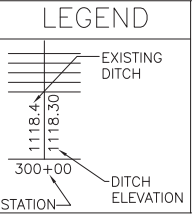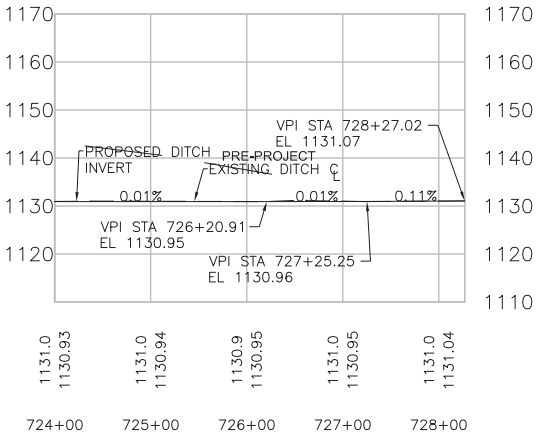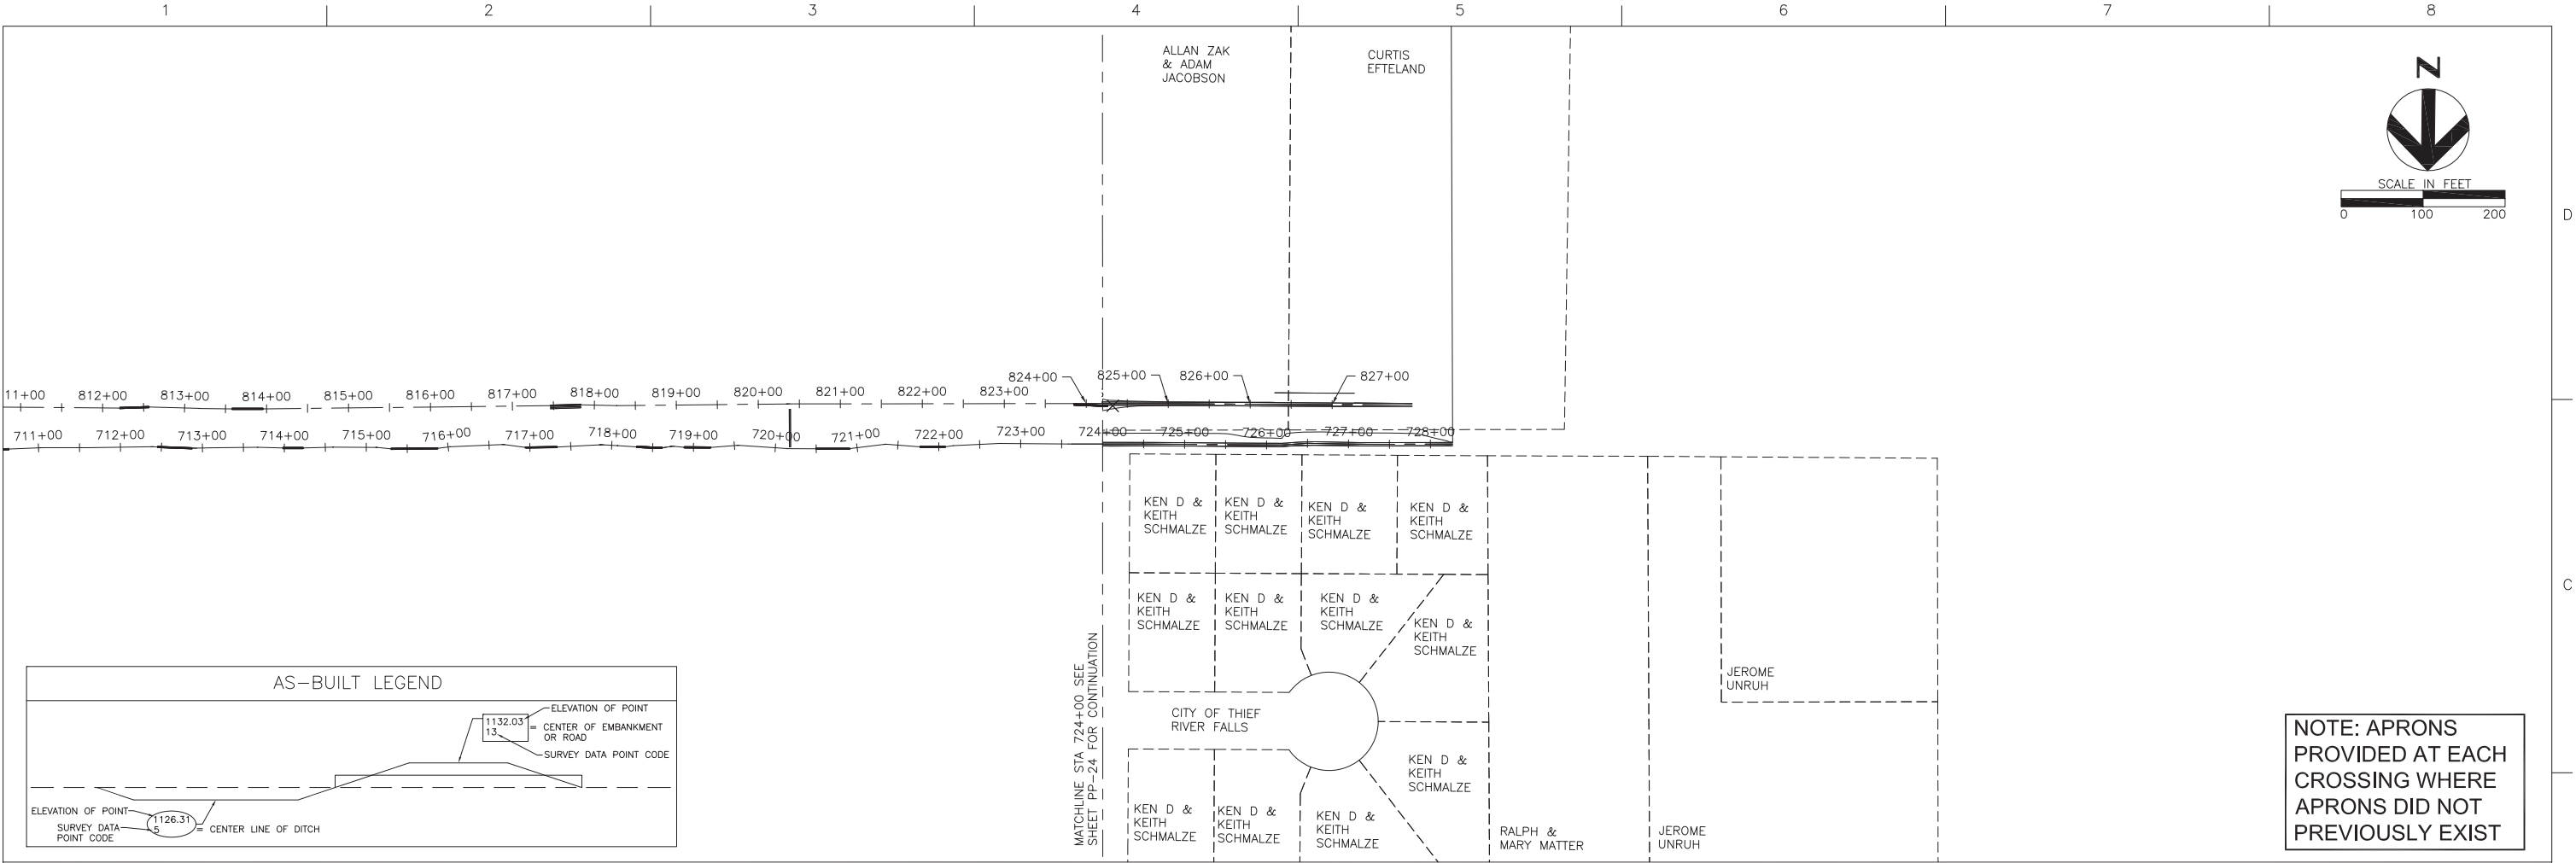

AS-BUILT - JANUARY 2013

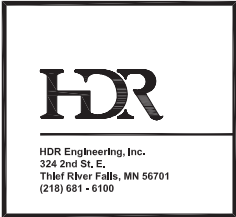

ISSUE	DATE	DESCRIPTION

PROJECT MANAGER	Nathan P. Dalager
DESIGNED	G. Hufnagle
DESIGNED	B. Hauth
CHECKED	M. Redington
CHECKED	
DRAWN	
DRAWN	
PROJECT NUMBER	131515

I HEREBY CERTIFY THAT THIS PLAN, SPECIFICATION, OR REPORT WAS PREPARED BY ME OR UNDER MY DIRECT SUPERVISION AND THAT I AM A DULY REGISTERED PROFESSIONAL ENGINEER UNDER THE LAWS OF THE STATE OF MINNESOTA.

DATE 1/21/2013 REG. NO. 25309

Nathan P. Dalager

Nathan P. Dalager

Red Lake Watershed District



1000 PENNINGTON AVE.
THIEF RIVER FALLS, MN 56701 (218) 681-5800

THIEF RIVER FALLS FLOOD DAMAGE REDUCTION PROJECT AND IMPROVEMENT TO PENNINGTON COUNTY DITCH #1 (RLWD DITCH #14)

TRF FLOOD DAMAGE REDUCTION PROJECT
COUNTY ROAD 62 - NORTH DITCH
WEST OF RLWD DITCH #14
PLAN AND PROFILE STA 724+00 TO 728+00


0 1/2" 1"

FILENAME OOC-PP04-02.dwg SHEET PP-25

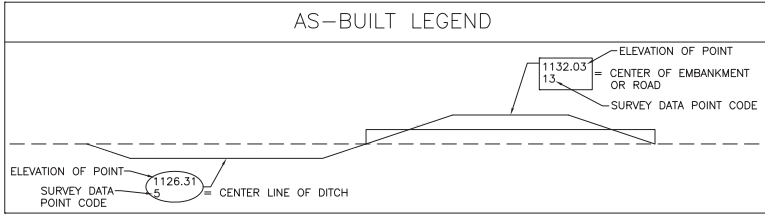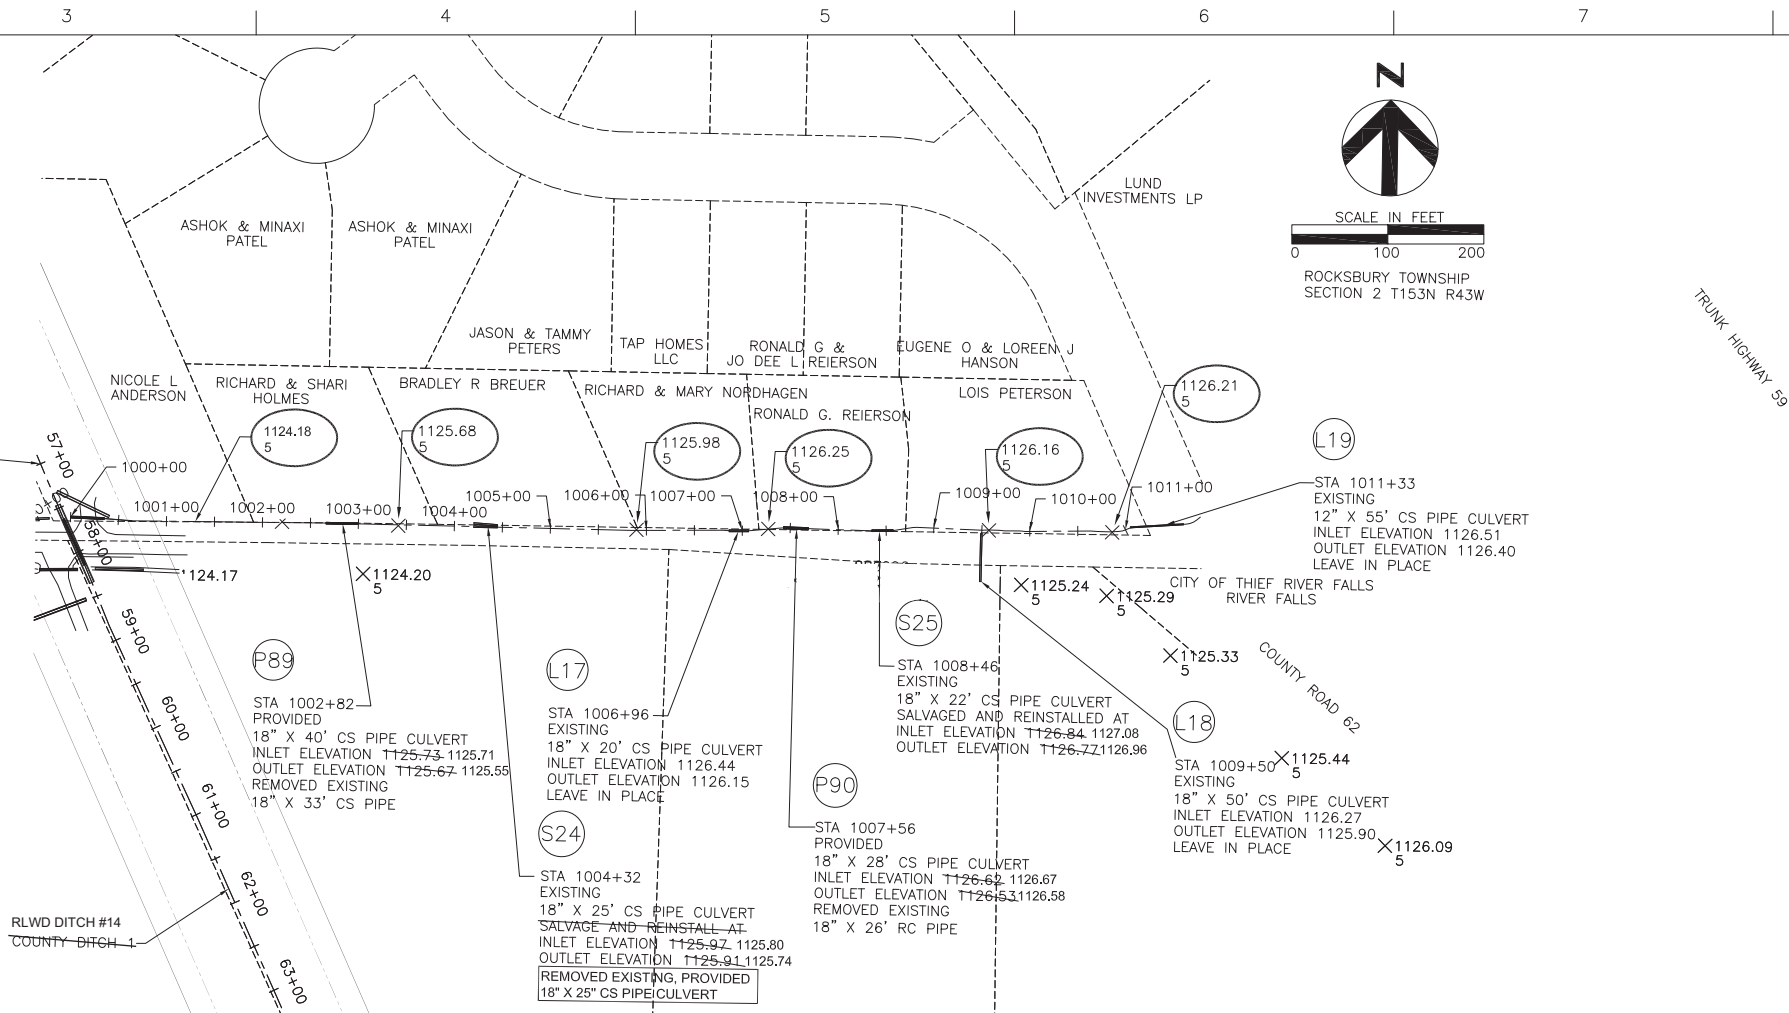


NOTE: APRONS PROVIDED AT EACH CROSSING WHERE APRONS DID NOT PREVIOUSLY EXIST

SEE PLAN VIEW (ABOVE) FOR AS-BUILT PIPE INFORMATION

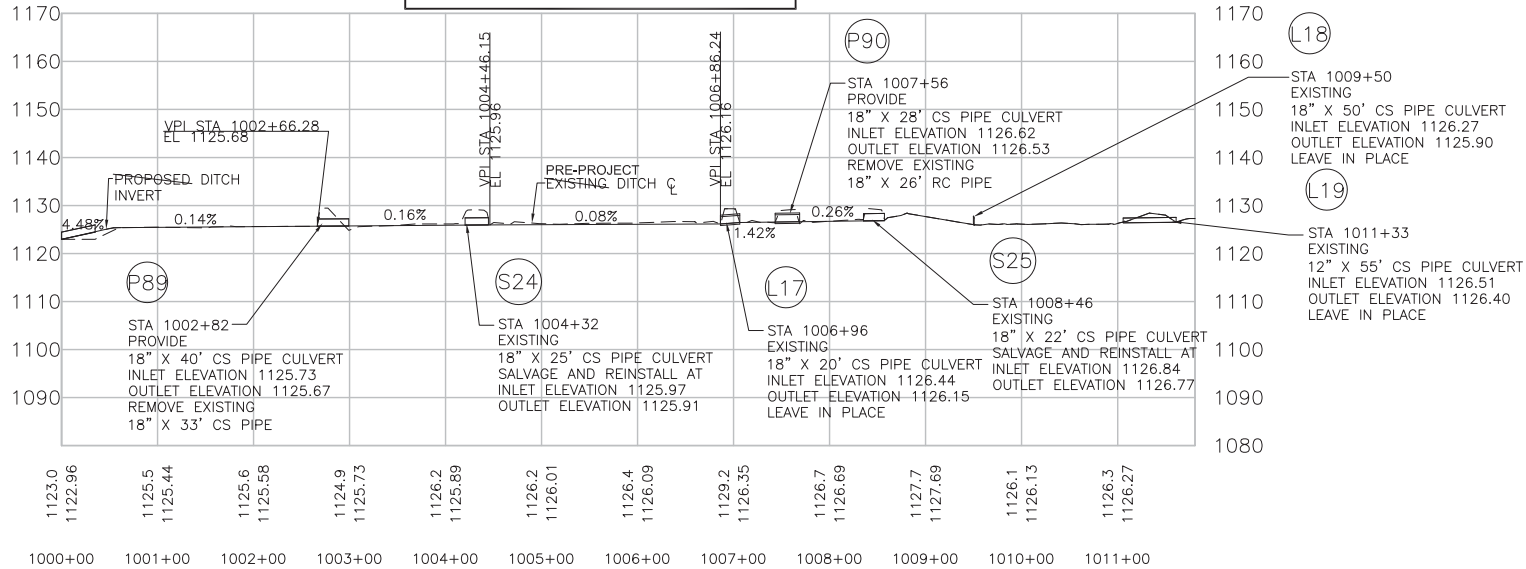

NOTE: SEE UT-24 & UT-25 FOR UTILITY COORDINATION AND RELOCATION INSTRUCTIONS

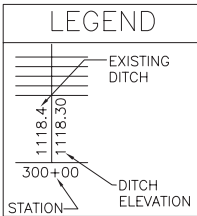

AS-BUILT - JANUARY 2013



HDR Engineering, Inc.
324 2nd St. E.
Thief River Falls, MN 56701
(218) 681-6100

			PROJECT MANAGER	Nathan P. Dalager
			DESIGNED	B. Hauth
			DESIGNED	G. Hufnagle
			CHECKED	M. Redington
			CHECKED	
			DRAWN	
			DRAWN	
ISSUE	DATE	DESCRIPTION	PROJECT NUMBER	131515

I HEREBY CERTIFY THAT THIS PLAN, SPECIFICATION, OR REPORT WAS PREPARED BY ME OR UNDER MY DIRECT SUPERVISION AND THAT I AM A DULY REGISTERED PROFESSIONAL ENGINEER UNDER THE LAWS OF THE STATE OF MINNESOTA.

DATE 1/21/2013 REG. NO. 25309

Nathan P. Dalager
Nathan P. Dalager

Red Lake
Watershed District

1000 PENNINGTON AVE.
THIEF RIVER FALLS, MN
56701 (218) 681-5800




THIEF RIVER FALLS FLOOD DAMAGE REDUCTION
PROJECT AND IMPROVEMENT TO PENNINGTON
COUNTY DITCH #1 (RLWD DITCH #14)

TRF FLOOD DAMAGE REDUCTION PROJECT
COUNTY ROAD 62 - NORTH DITCH
EAST OF RLWD DITCH #14
PLAN AND PROFILE STA 1000+00 TO 1011+81



FILENAME OOC-PP04-05.dwg

SHEET
PP-26

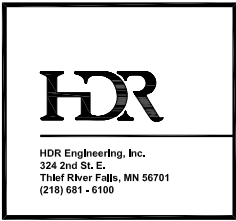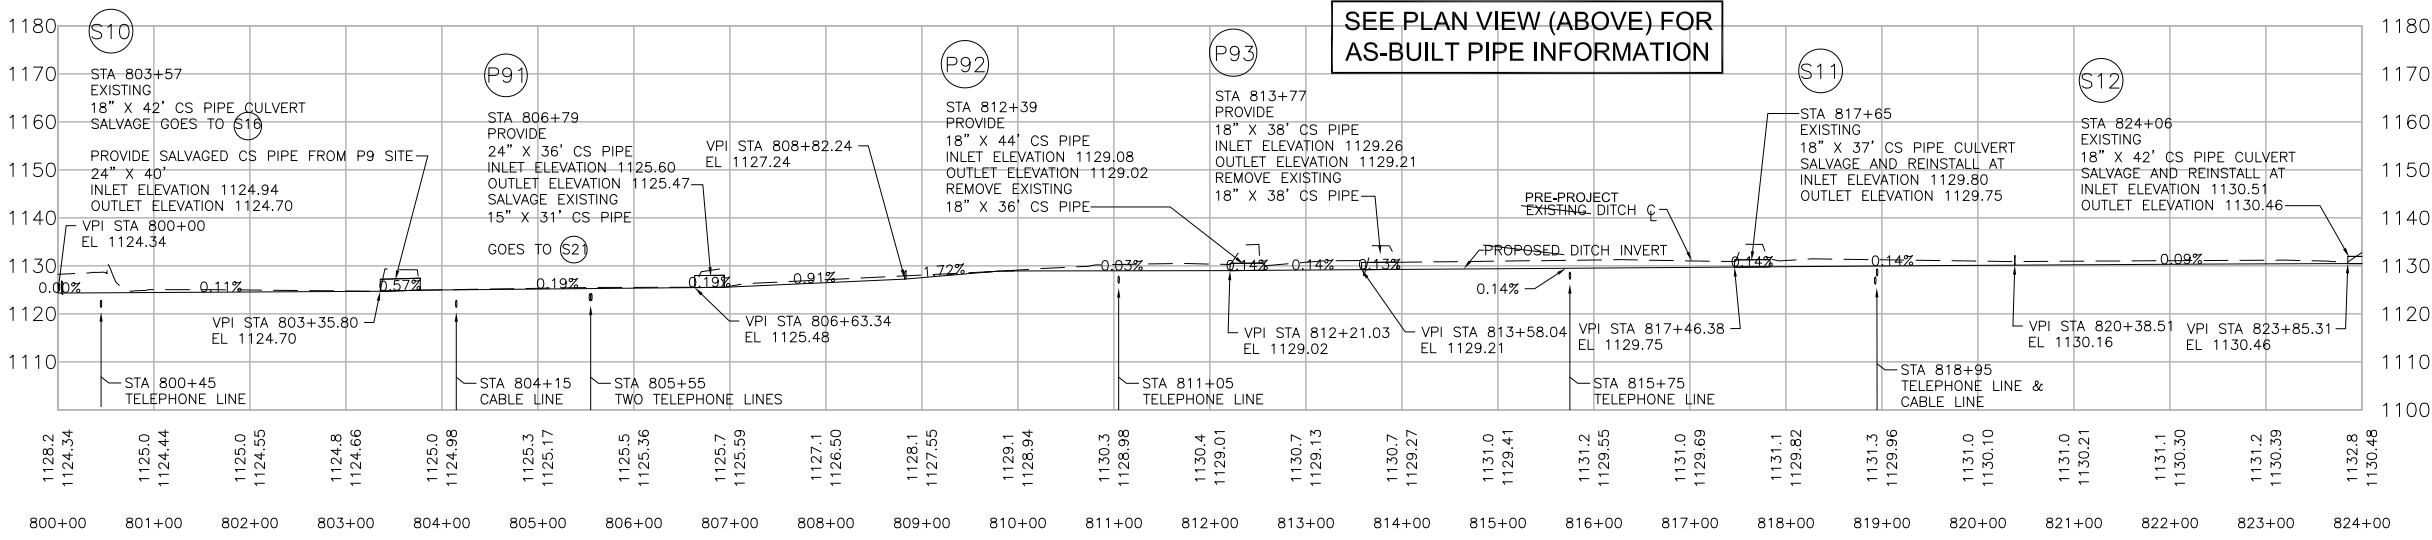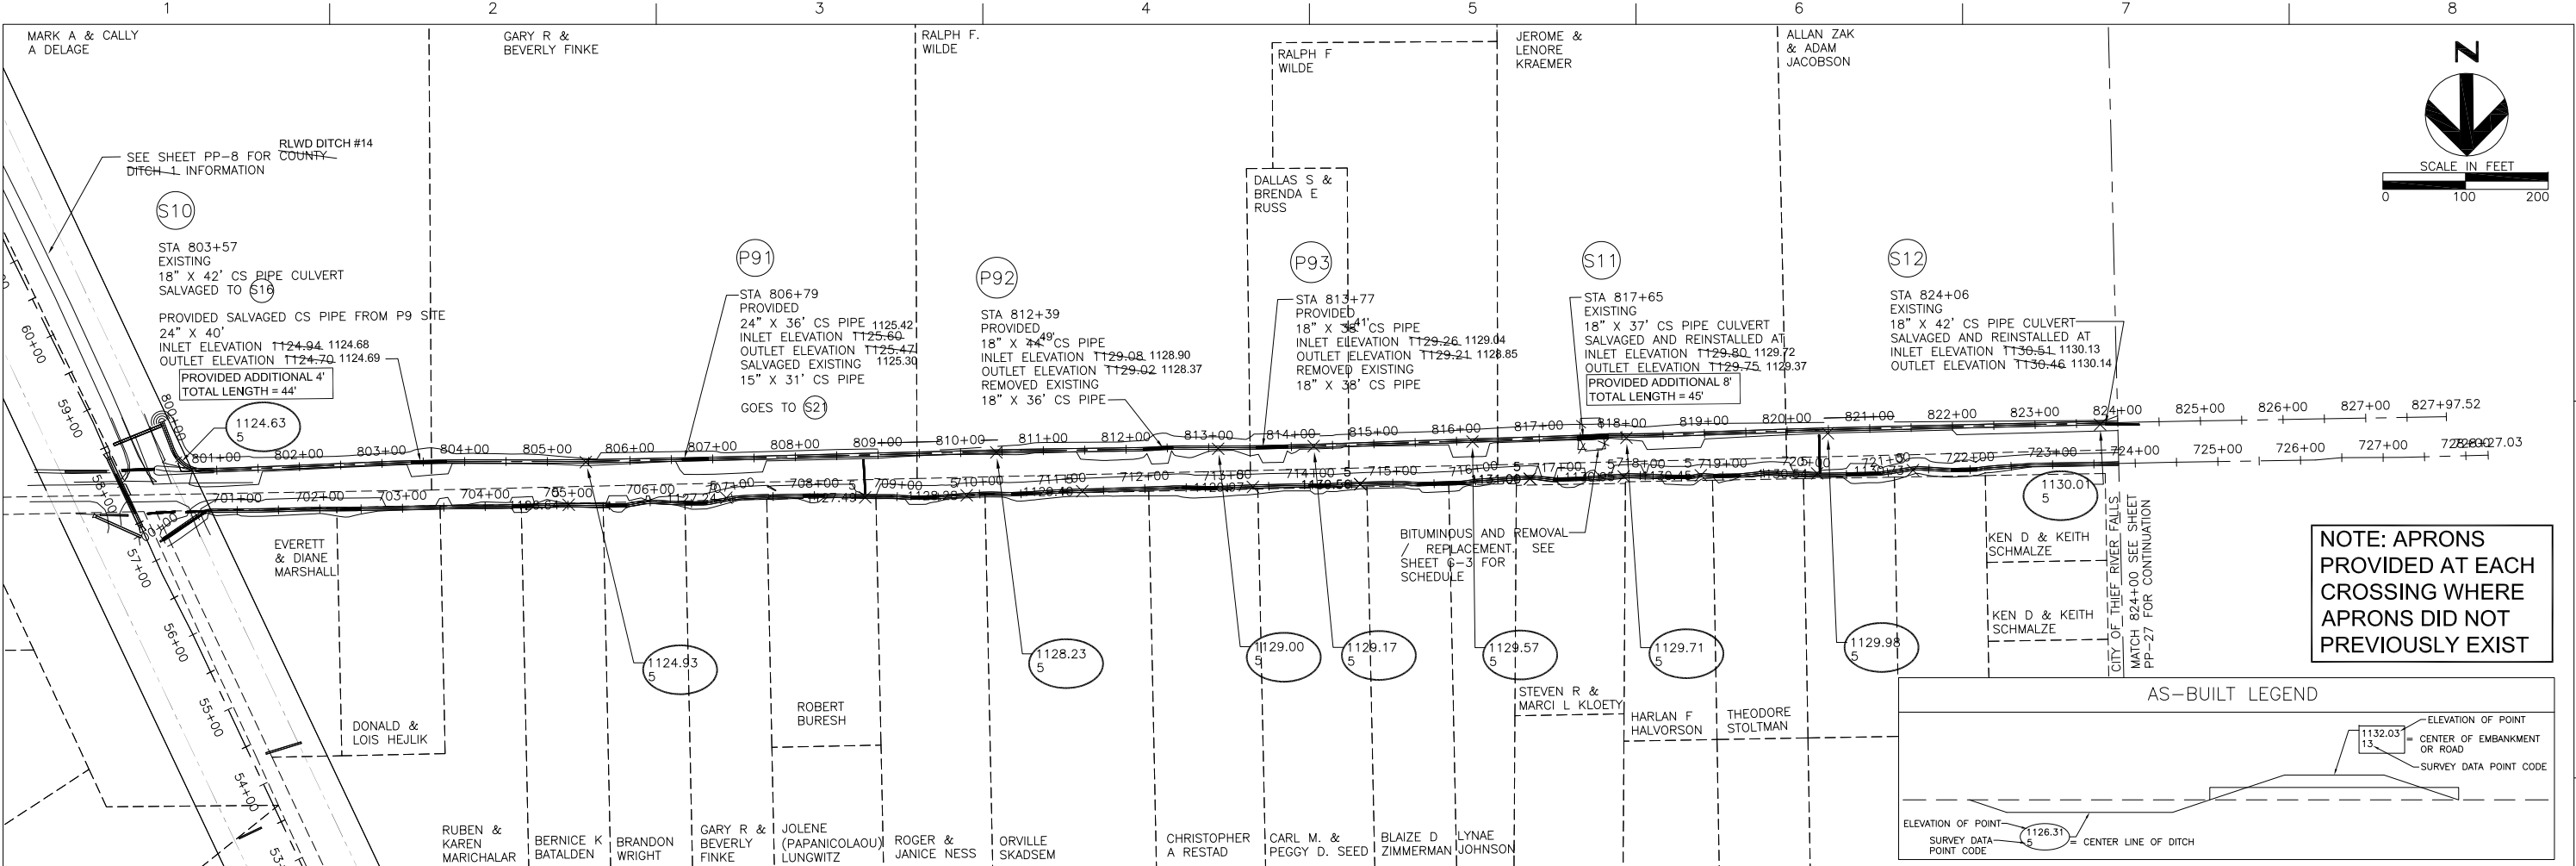

ISSUE	DATE	DESCRIPTION

PROJECT MANAGER	Nathan P. Dalager
DESIGNED	B. Hauth
DESIGNED	G. Hufnagle
CHECKED	M. Redington
CHECKED	
DRAWN	
DRAWN	
PROJECT NUMBER	131515

I HEREBY CERTIFY THAT THIS PLAN, SPECIFICATION, OR REPORT WAS PREPARED BY ME OR UNDER MY DIRECT SUPERVISION AND THAT I AM A DULY REGISTERED PROFESSIONAL ENGINEER UNDER THE LAWS OF THE STATE OF MINNESOTA.

DATE 1/21/2013 REG. NO. 25309

Nathan P. Dalager

Nathan P. Dalager

Red Lake Watershed District

1000 PENNINGTON AVE.
THIEF RIVER FALLS, MN
56701 (218) 681-5800



THIEF RIVER FALLS FLOOD DAMAGE REDUCTION PROJECT AND IMPROVEMENT TO PENNINGTON COUNTY DITCH #1 (RLWD DITCH #14)

AS-BUILT - JANUARY 2013



**TRF FLOOD DAMAGE REDUCTION PROJECT
COUNTY ROAD 62 - SOUTH DITCH
WEST OF RLWD DITCH #14
PLAN AND PROFILE STA 800+00 TO 824+00**

0 1/2" 1"

FILENAME OOC-PP04-03.dwg SHEET PP-27

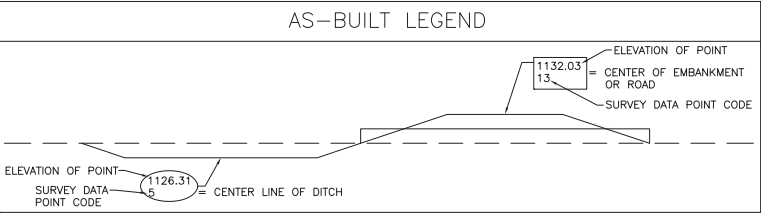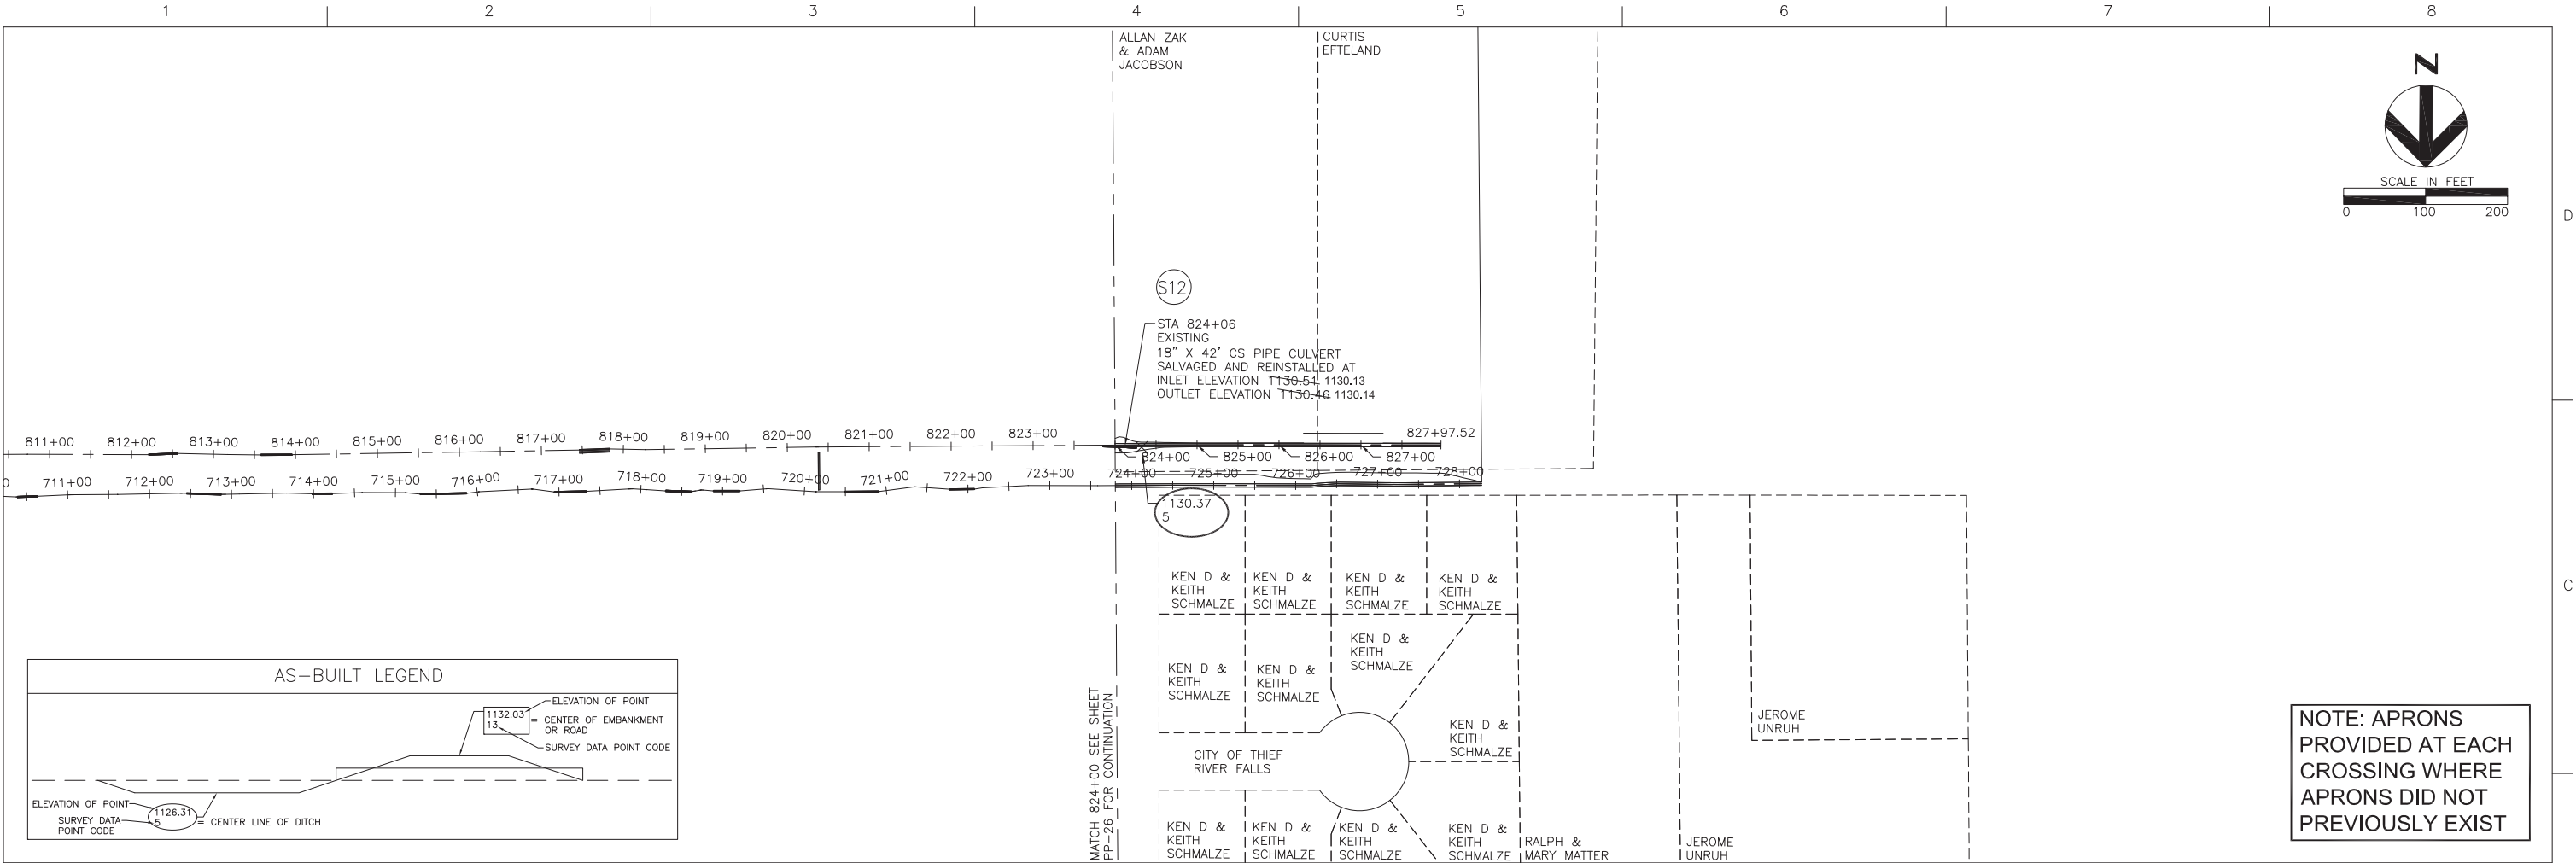

SEE PLAN VIEW (ABOVE) FOR
AS-BUILT PIPE INFORMATION

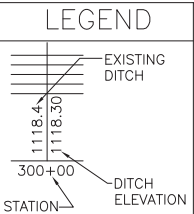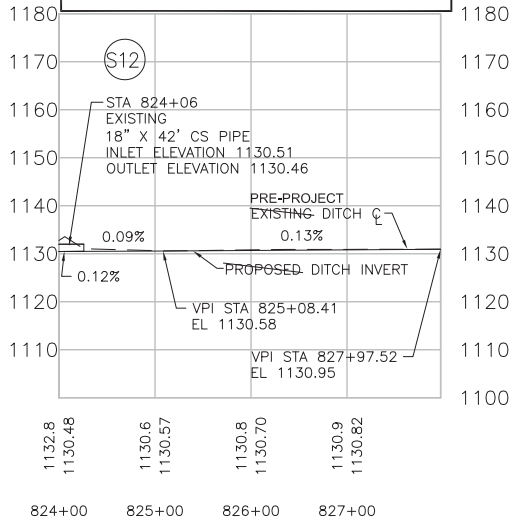

AS-BUILT - JANUARY 2013



HDR Engineering, Inc.
324 2nd St. E.
Thief River Falls, MN 56701
(218) 681-6100

			PROJECT MANAGER	Nathan P. Dalager
			DESIGNED	B. Hauth
			DESIGNED	G. Hufnagle
			CHECKED	M. Redington
			CHECKED	
			DRAWN	
			DRAWN	
ISSUE	DATE	DESCRIPTION	PROJECT NUMBER	131515

I HEREBY CERTIFY THAT THIS PLAN, SPECIFICATION, OR REPORT WAS PREPARED BY ME OR UNDER MY DIRECT SUPERVISION AND THAT I AM A DULY REGISTERED PROFESSIONAL ENGINEER UNDER THE LAWS OF THE STATE OF MINNESOTA.

DATE 1/21/2013 REG. NO. 25309

Nathan P. Dalager

Red Lake
Watershed District

1000 PENNINGTON AVE.
THIEF RIVER FALLS, MN
56701 (218) 681-5800

THIEF RIVER FALLS FLOOD DAMAGE REDUCTION
PROJECT AND IMPROVEMENT TO PENNINGTON
COUNTY DITCH #1 (RLWD DITCH #14)



TRF FLOOD DAMAGE REDUCTION PROJECT
COUNTY ROAD 62 - SOUTH DITCH
WEST OF RLWD DITCH #14
PLAN AND PROFILE STA 824+00 TO 827+98



FILENAME OOC-PP04-04.dwg

SHEET

PP-28

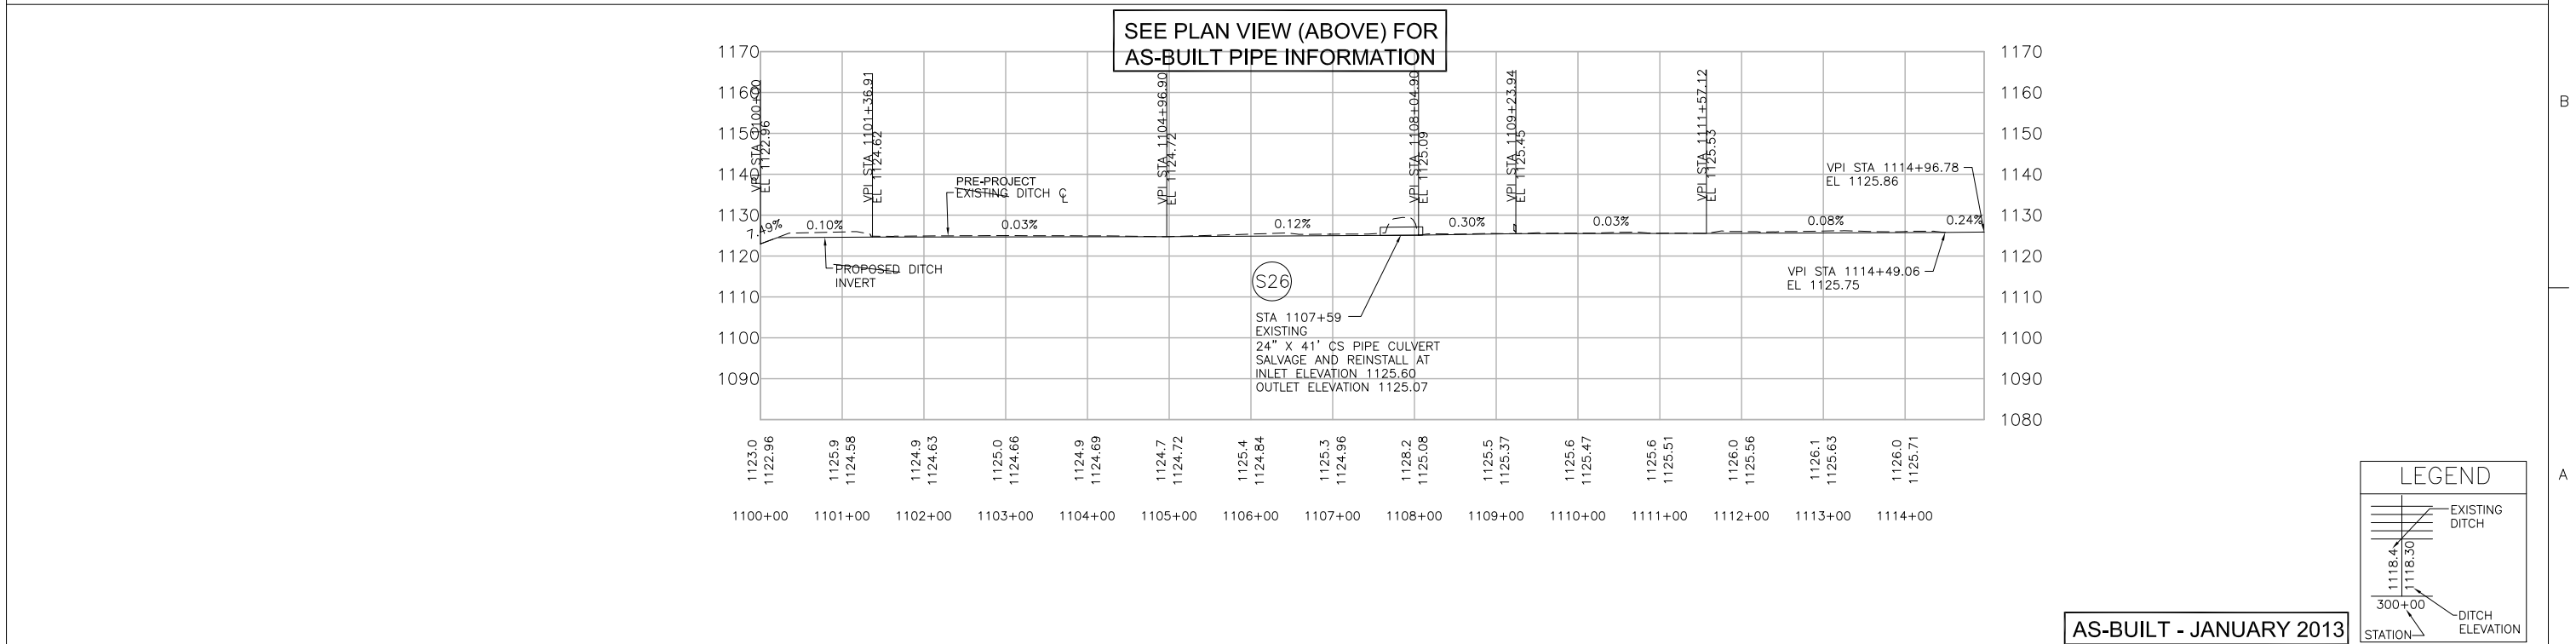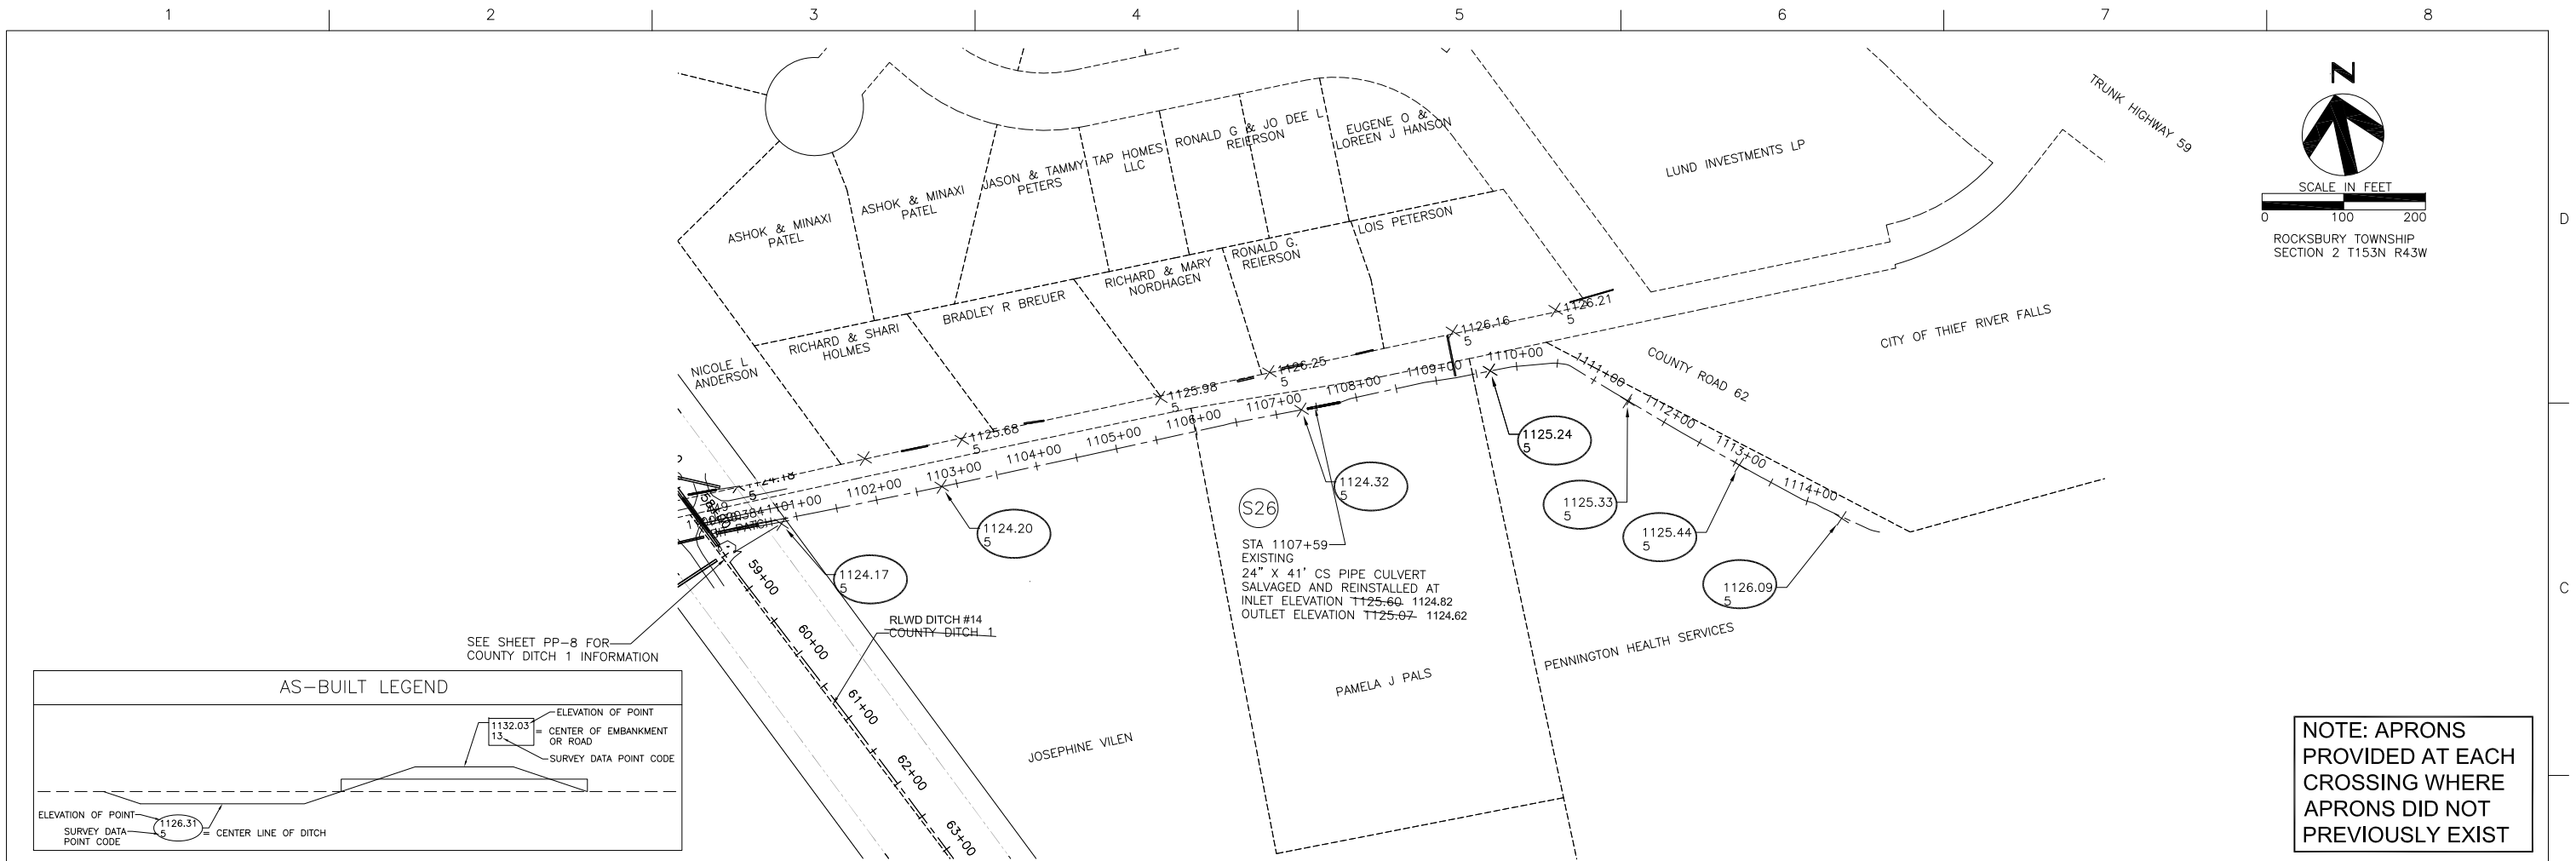

HDR Engineering, Inc.
324 2nd St. E.
Thief River Falls, MN 56701
(218) 681-6100

			PROJECT MANAGER	Nathan P. Dalager
			DESIGNED	B. Hauth
			DESIGNED	G. Hufnagle
			CHECKED	M. Redington
			CHECKED	
			DRAWN	
			DRAWN	
ISSUE	DATE	DESCRIPTION	PROJECT NUMBER	131515

 
I HEREBY CERTIFY THAT THIS PLAN, SPECIFICATION, OR REPORT WAS PREPARED BY ME OR UNDER MY DIRECT SUPERVISION AND THAT I AM A DULY REGISTERED PROFESSIONAL ENGINEER UNDER THE LAWS OF THE STATE OF MINNESOTA.

DATE 1/21/2013 REG. NO. 25309
Nathan P. Dalager
Nathan P. Dalager

Red Lake Watershed District
1000 PENNINGTON AVE.
THIEF RIVER FALLS, MN 56701
(218) 681-5800


THIEF RIVER FALLS FLOOD DAMAGE REDUCTION PROJECT AND IMPROVEMENT TO PENNINGTON COUNTY DITCH #1 (RLWD DITCH #14)

TRF FLOOD DAMAGE REDUCTION PROJECT
COUNTY ROAD 62 - SOUTH DITCH
EAST OF RLWD DITCH #14
PLAN AND PROFILE STA 1100+00 TO 1114+97




FILENAME 00C-PP04-06.dwg

SHEET PP-29

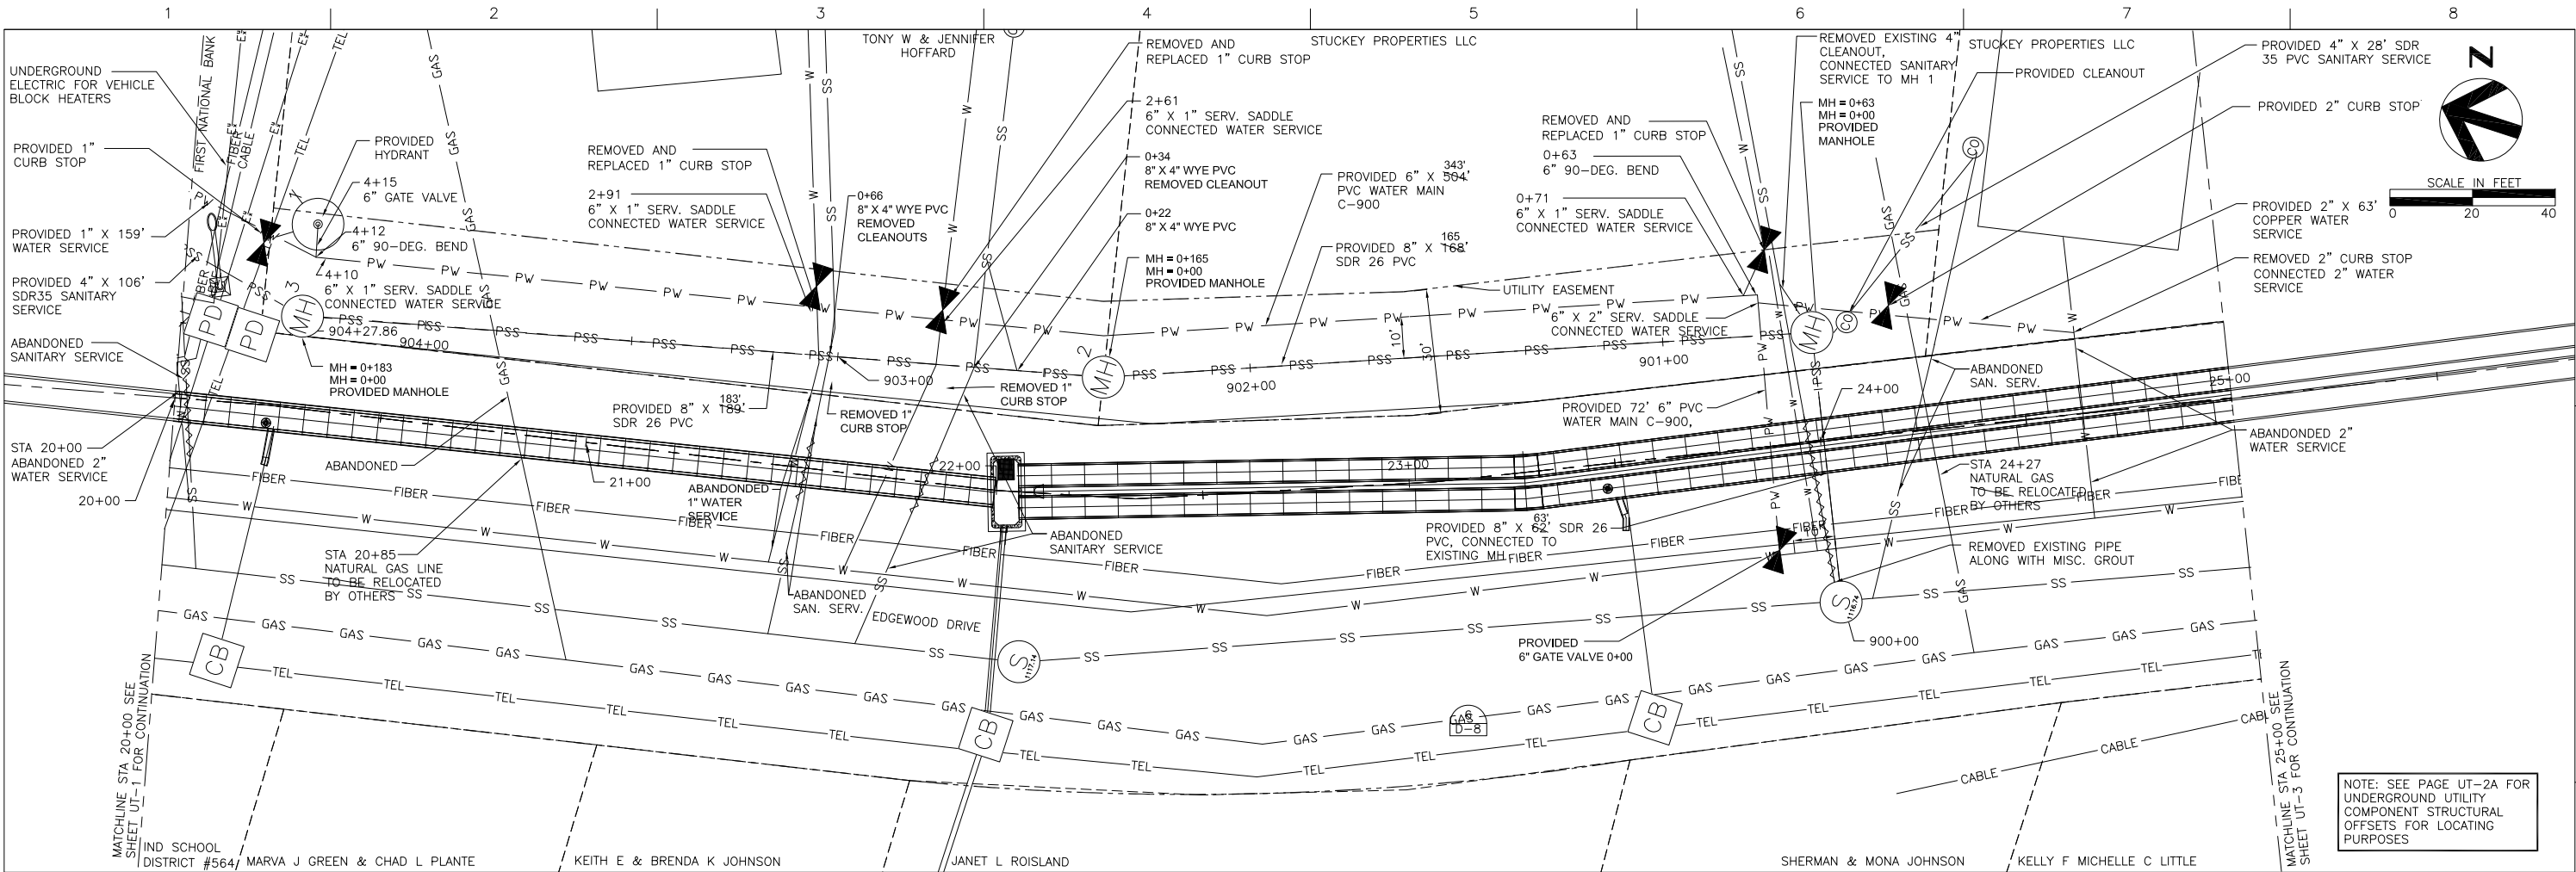

SANITARY SEWER PROFILE

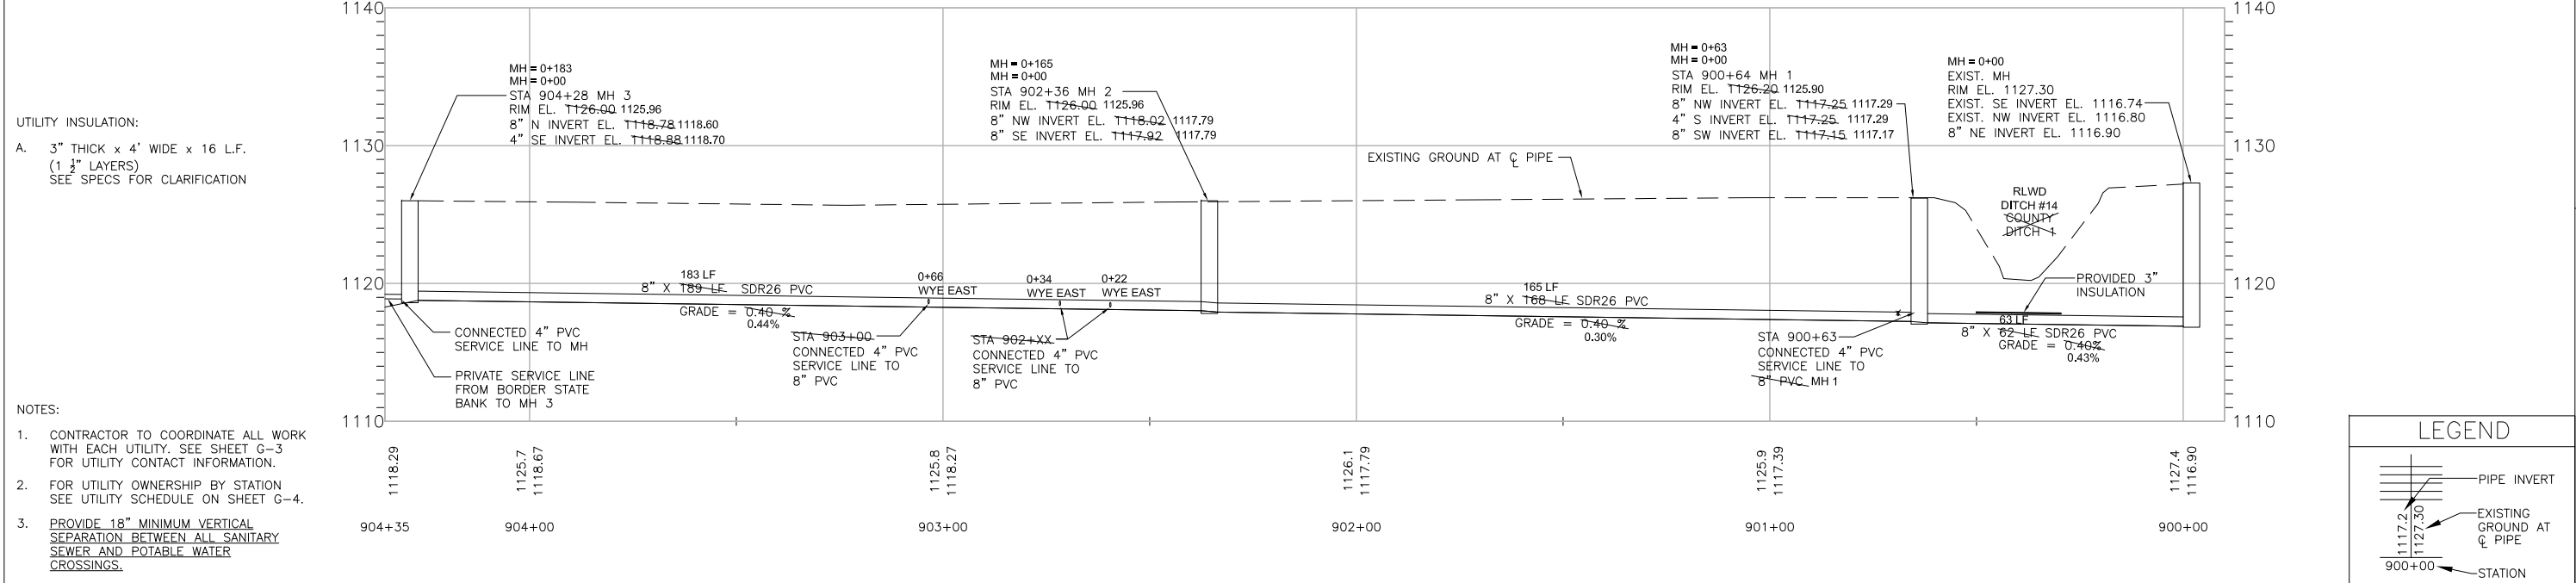

ISSUE	DATE	DESCRIPTION

PROJECT MANAGER	Nathan P. Dalager
DESIGNED	M. Peterson
DESIGNED	G. Hufnagle
CHECKED	M. Redington
CHECKED	R. Knott
DRAWN	
DRAWN	
PROJECT NUMBER	131515

I HEREBY CERTIFY THAT THIS PLAN, SPECIFICATION, OR REPORT WAS PREPARED BY ME OR UNDER MY DIRECT SUPERVISION AND THAT I AM A DULY REGISTERED PROFESSIONAL ENGINEER UNDER THE LAWS OF THE STATE OF MINNESOTA.

DATE 1/21/2013 REG. NO. 25309

Nathan P. Dalager

Nathan P. Dalager

Red Lake Watershed District


1000 PENNINGTON AVE.
THIEF RIVER FALLS, MN 56701
(218) 681-5800

THIEF RIVER FALLS FLOOD DAMAGE REDUCTION PROJECT AND IMPROVEMENT TO PENNINGTON COUNTY DITCH #1 (RLWD DITCH #14)


**TRF FLOOD DAMAGE REDUCTION PROJECT
STORM SEWER UTILITY PLAN
STA 20+00 TO 25+00
AS-BUILT - JANUARY 2013**

0 1/2" 1"

FILENAME OOC-UT05-02.dwg SHEET UT-2

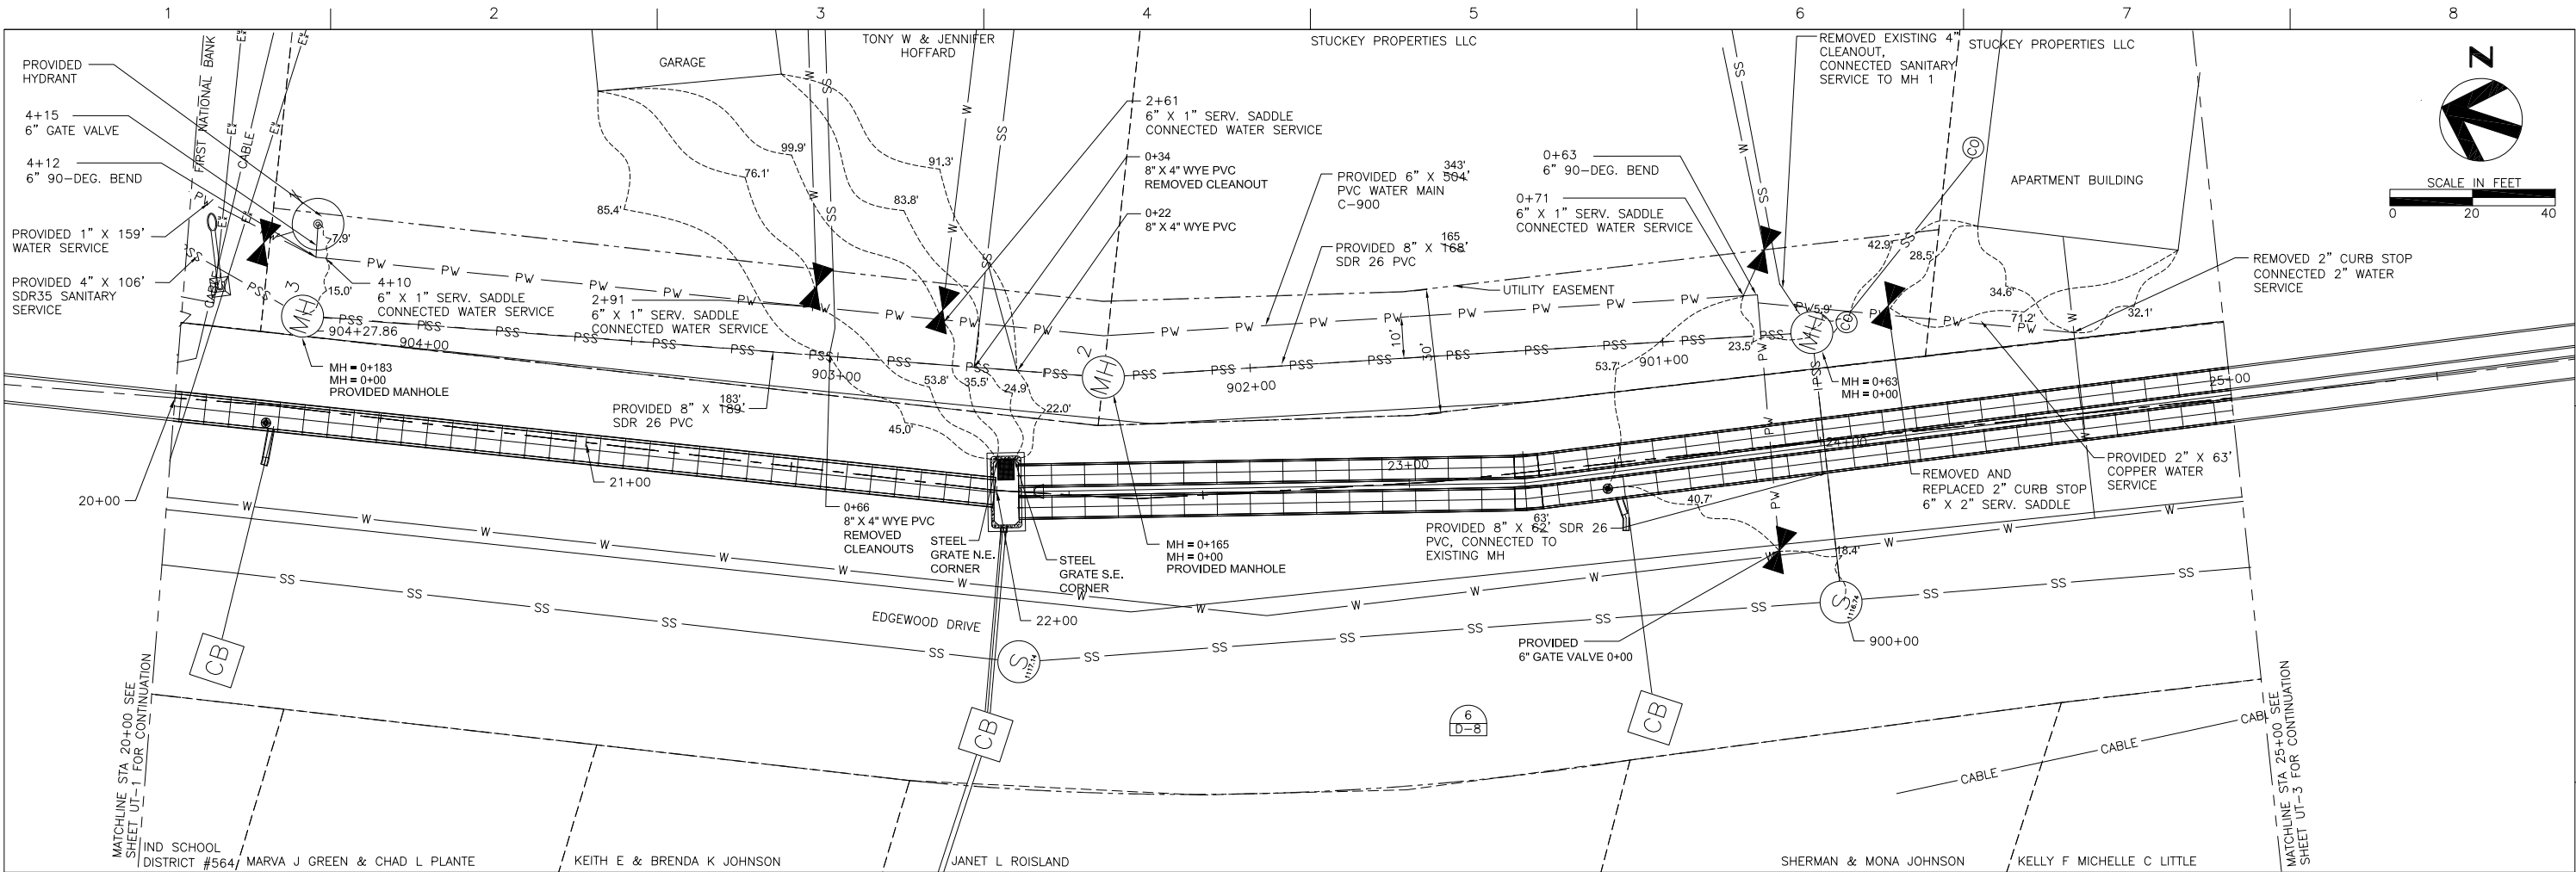

SANITARY SEWER PROFILE

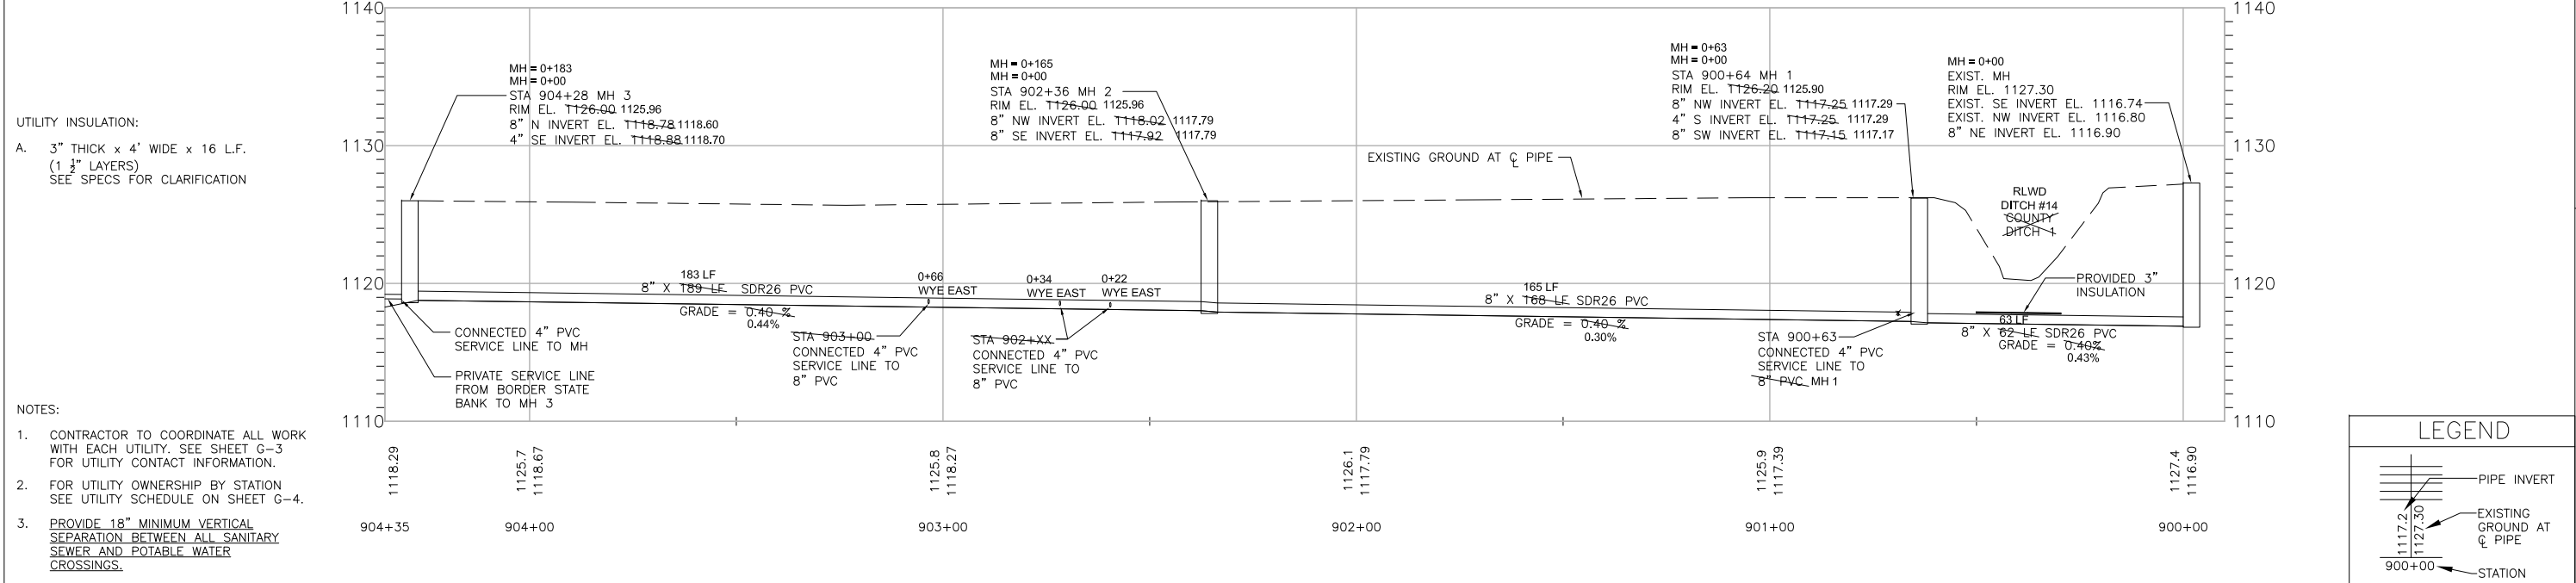

UTILITY INSULATION:
A. 3" THICK x 4" WIDE x 16 L.F.
(1 1/2" LAYERS)
SEE SPECS FOR CLARIFICATION

- NOTES:
- CONTRACTOR TO COORDINATE ALL WORK WITH EACH UTILITY. SEE SHEET G-3 FOR UTILITY CONTACT INFORMATION.
 - FOR UTILITY OWNERSHIP BY STATION SEE UTILITY SCHEDULE ON SHEET G-4.
 - PROVIDE 18" MINIMUM VERTICAL SEPARATION BETWEEN ALL SANITARY SEWER AND POTABLE WATER CROSSINGS.



			PROJECT MANAGER	Nathan P. Dalager
			DESIGNED	M. Peterson
			DESIGNED	G. Hufnagle
			CHECKED	M. Redington
			CHECKED	R. Knott
			DRAWN	
			DRAWN	
ISSUE	DATE	DESCRIPTION	PROJECT NUMBER	131515

I HEREBY CERTIFY THAT THIS PLAN, SPECIFICATION, OR REPORT WAS PREPARED BY ME OR UNDER MY DIRECT SUPERVISION AND THAT I AM A DULY REGISTERED PROFESSIONAL ENGINEER UNDER THE LAWS OF THE STATE OF MINNESOTA.

DATE 1/21/2013 REG. NO. 25309

Nathan P. Dalager

Nathan P. Dalager

Red Lake Watershed District



1000 PENNINGTON AVE.
THIEF RIVER FALLS, MN 56701
(218) 681-5800

THIEF RIVER FALLS FLOOD DAMAGE REDUCTION PROJECT AND IMPROVEMENT TO PENNINGTON COUNTY DITCH #1 (RLWD DITCH #14)

**TRF FLOOD DAMAGE REDUCTION PROJECT
STORM SEWER UTILITY PLAN
STA 20+00 TO 25+00
AS-BUILT - JANUARY 2013**

0 1/2" 1"

FILENAME OOC-UT05-02 LOCATED SHEET UT-2A

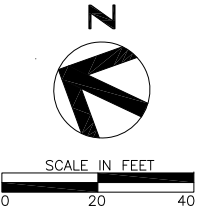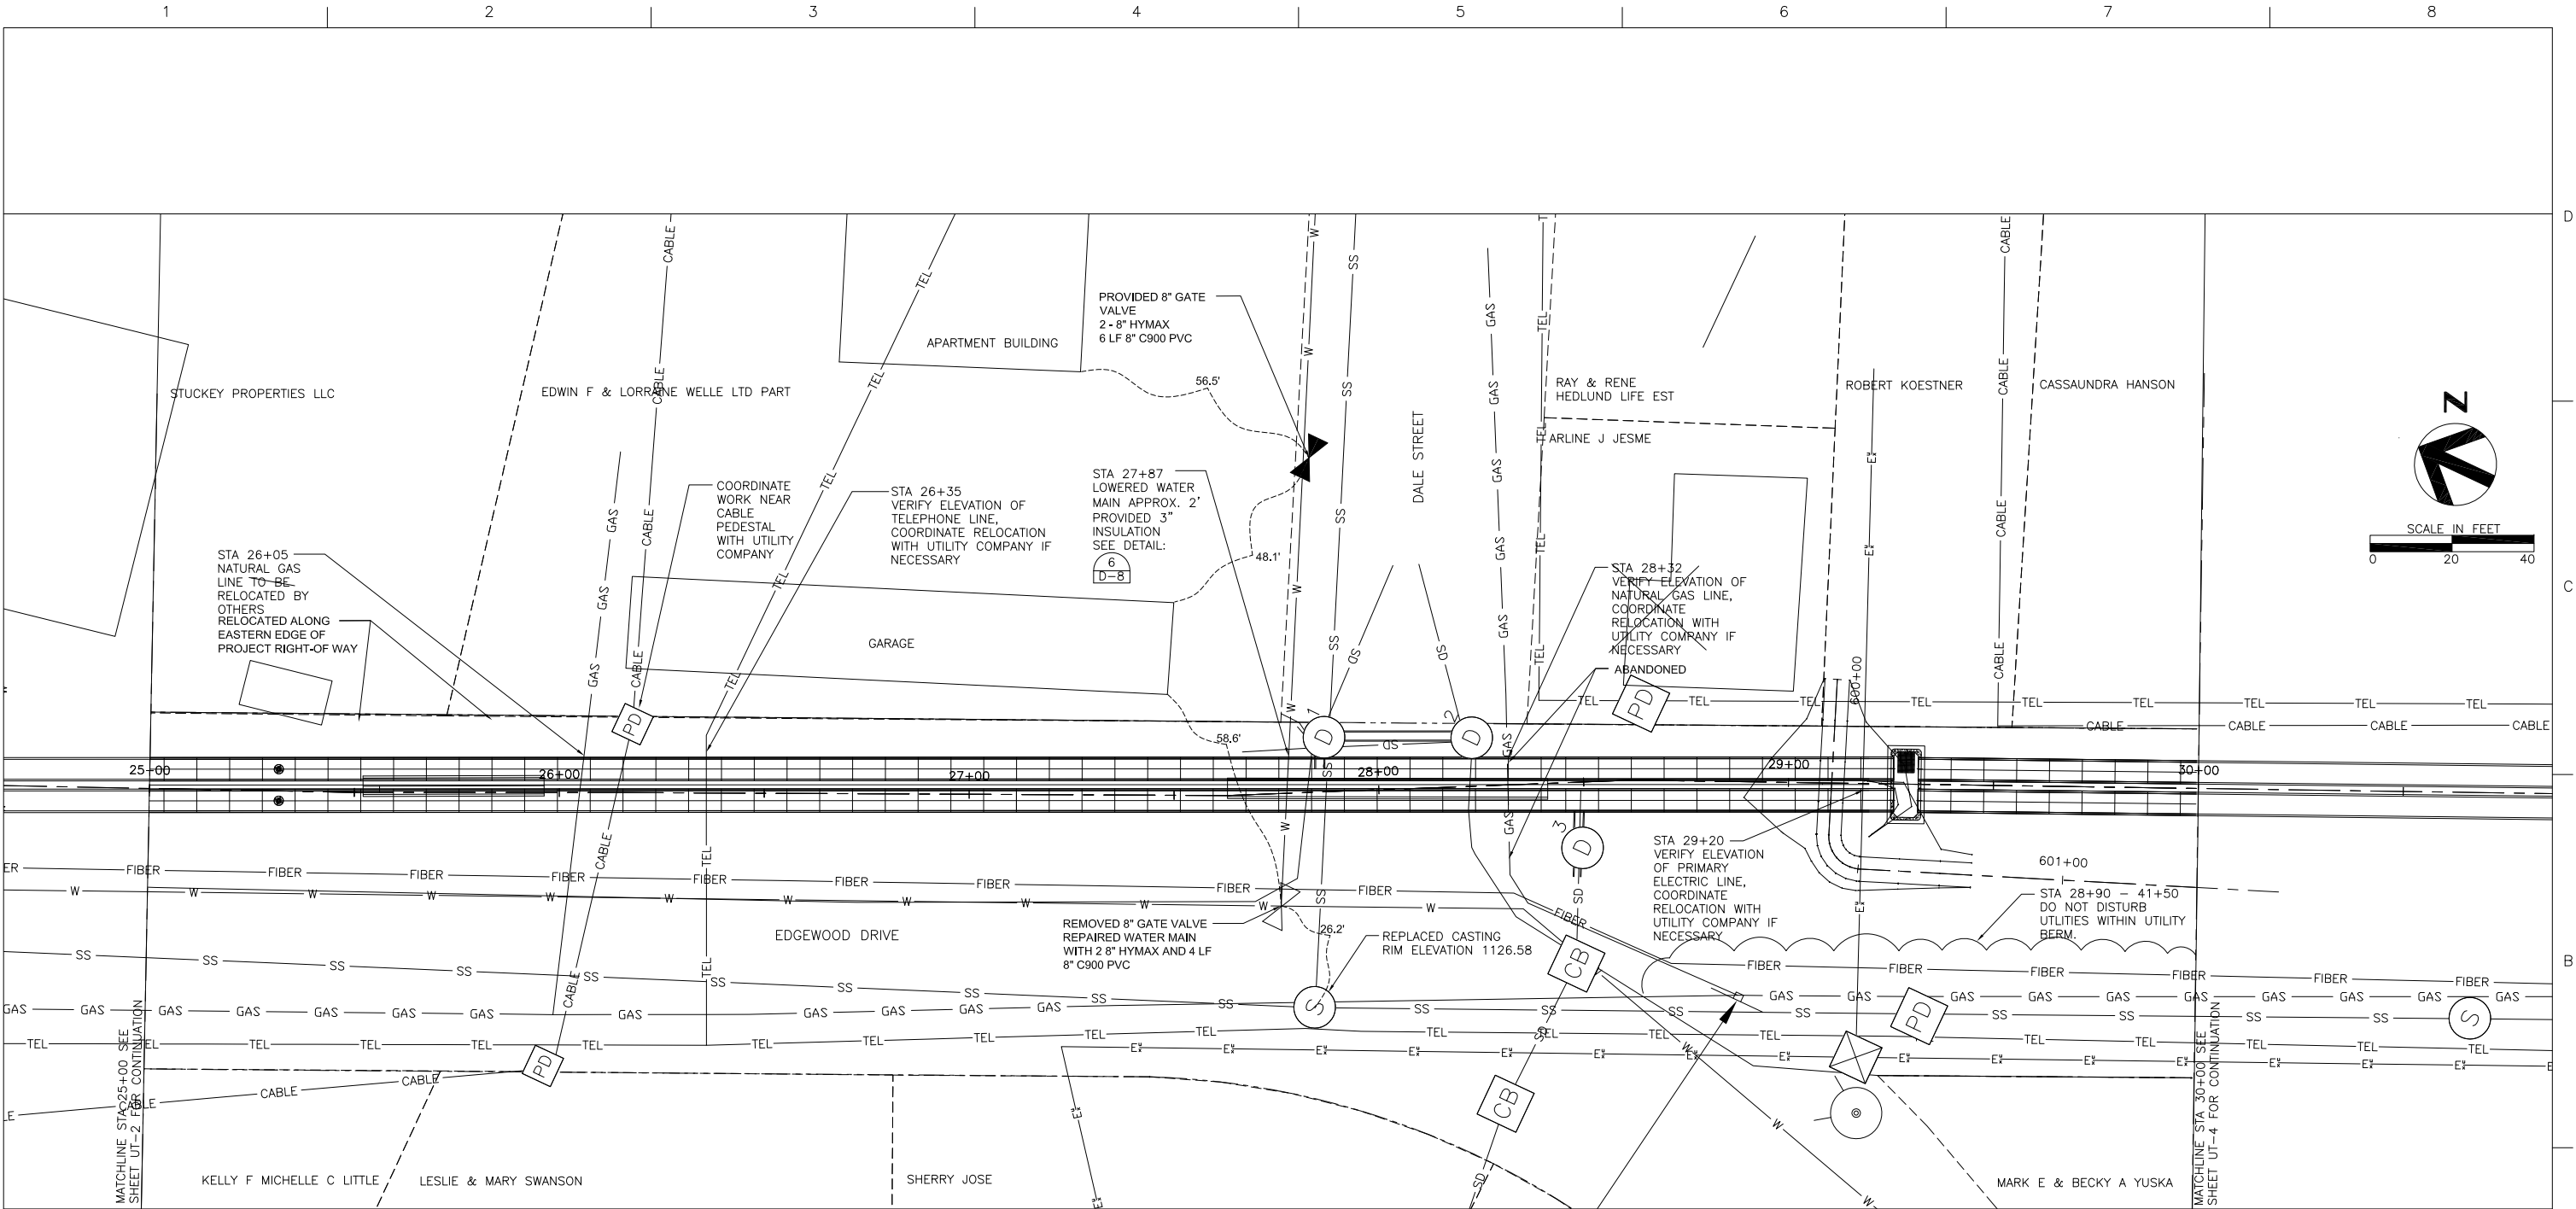

- NOTES:
1. CONTRACTOR TO COORDINATE ALL WORK WITH EACH UTILITY. SEE SHEET G-3 FOR UTILITY CONTACT INFORMATION.
 2. FOR UTILITY OWNERSHIP BY STATION SEE UTILITY SCHEDULE ON SHEET G-4.
- UTILITY INSULATION:
- A. 3" THICK x 4' WIDE x 24 L.F. (1 1/2" LAYERS)
SEE SPECS FOR CLARIFICATION



ISSUE	DATE	DESCRIPTION

PROJECT MANAGER	Nathan P. Dalager
DESIGNED	M. Peterson
DESIGNED	G. Hufnagle
CHECKED	M. Redington
CHECKED	R. Knott
DRAWN	
DRAWN	
PROJECT NUMBER	131515

I HEREBY CERTIFY THAT THIS PLAN, SPECIFICATION, OR REPORT WAS PREPARED BY ME OR UNDER MY DIRECT SUPERVISION AND THAT I AM A DULY REGISTERED PROFESSIONAL ENGINEER UNDER THE LAWS OF THE STATE OF MINNESOTA.

DATE 1/21/2013 REG. NO. 25309

Nathan P. Dalager

 
Nathan P. Dalager

Red Lake
Watershed District

1000 PENNINGTON AVE.
THIEF RIVER FALLS, MN
56701 (218) 681-5800



THIEF RIVER FALLS FLOOD DAMAGE REDUCTION
PROJECT AND IMPROVEMENT TO PENNINGTON
COUNTY DITCH #1 (RLWD DITCH #14)

TRF FLOOD DAMAGE REDUCTION PROJECT
STORM SEWER UTILITY PLAN
STA 25+00 TO 30+00
AS-BUILT - JANUARY 2013



FILENAME OOC-UT05-03.dwg

SHEET
UT-3

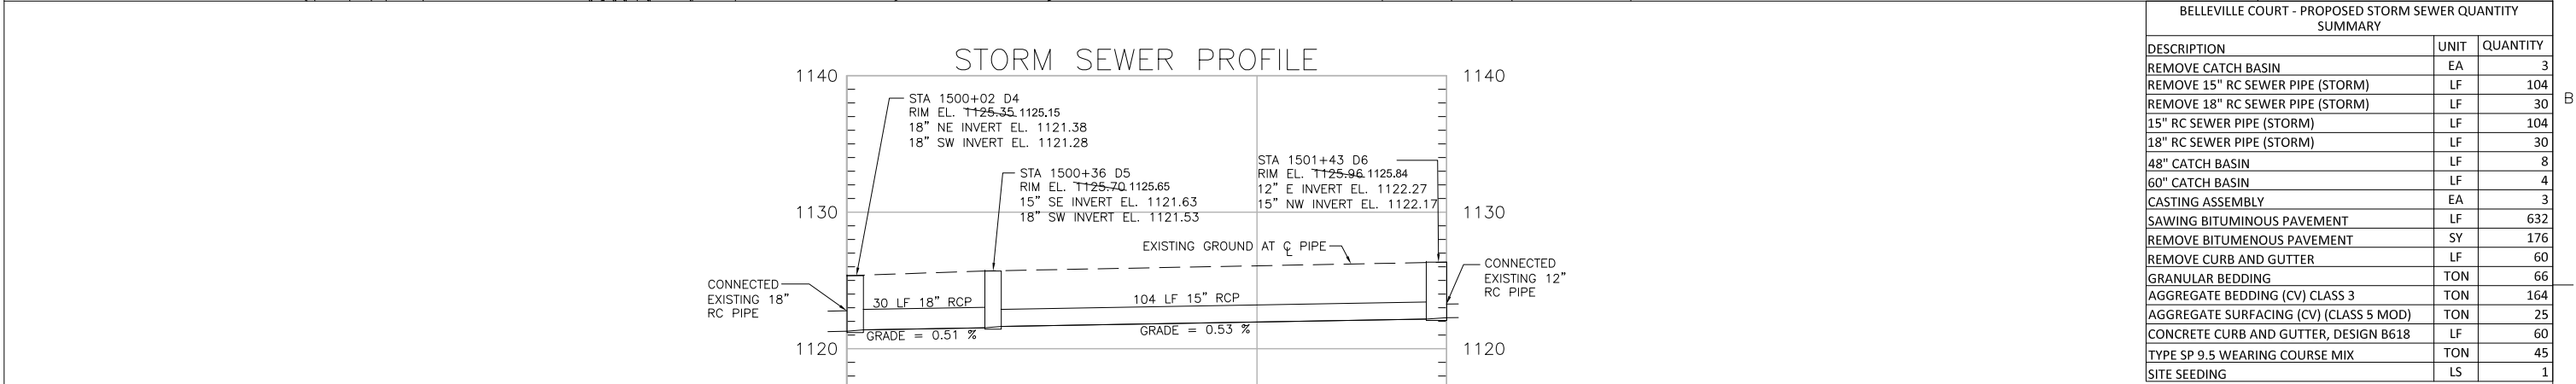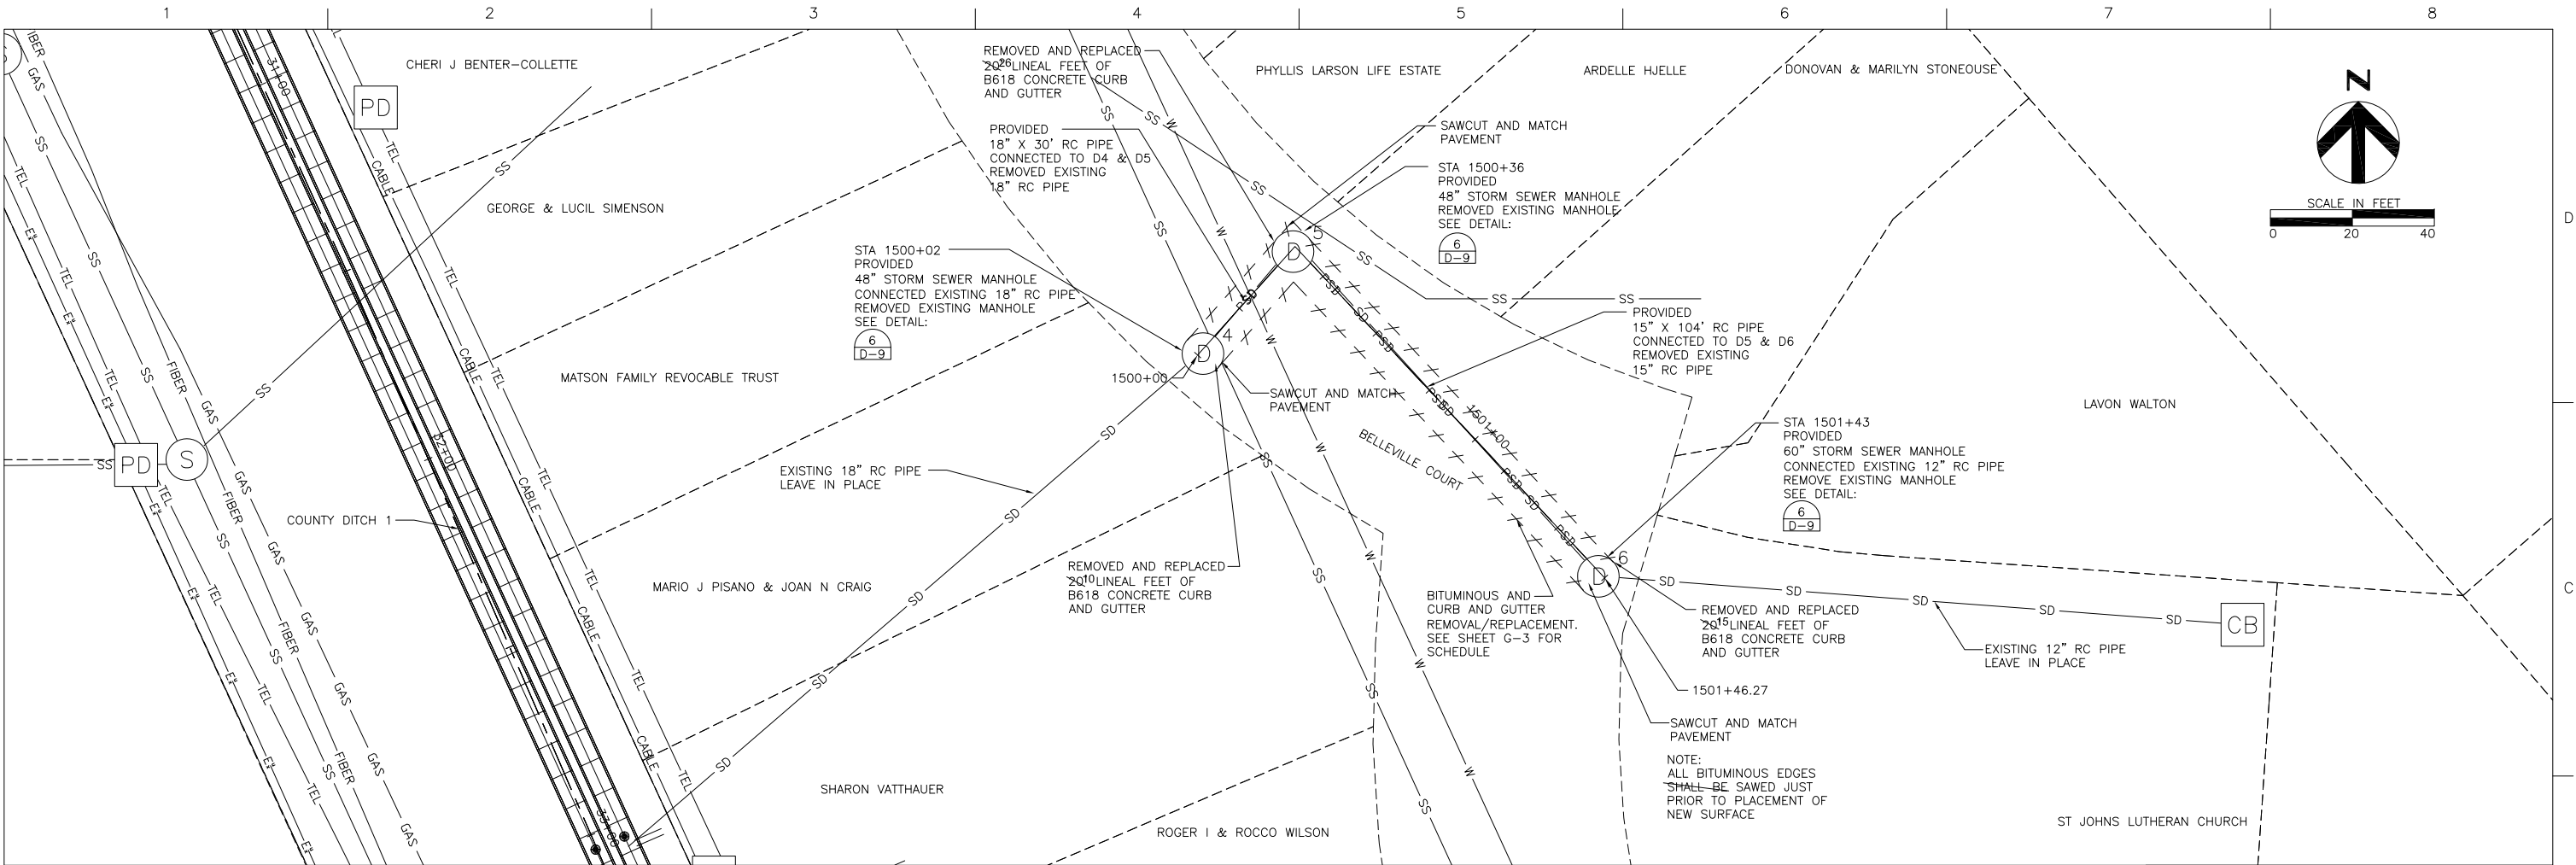

- NOTES:
- CONTRACTOR TO COORDINATE ALL WORK WITH EACH UTILITY. SEE SHEET G-3 FOR UTILITY CONTACT INFORMATION.
 - FOR UTILITY OWNERSHIP BY STATION SEE UTILITY SCHEDULE ON SHEET G-4.



			PROJECT MANAGER	Nathan P. Dalager
			DESIGNED	M. Peterson
			DESIGNED	G. Hufnagle
			CHECKED	M. Redington
			CHECKED	R. Knott
			DRAWN	
			DRAWN	
ISSUE	DATE	DESCRIPTION	PROJECT NUMBER	131515

I HEREBY CERTIFY THAT THIS PLAN, SPECIFICATION, OR REPORT WAS PREPARED BY ME OR UNDER MY DIRECT SUPERVISION AND THAT I AM A DULY REGISTERED PROFESSIONAL ENGINEER UNDER THE LAWS OF THE STATE OF MINNESOTA.

DATE 1/21/2013 REG. NO. 25309

Nathan P. Dalager

Nathan P. Dalager

Red Lake Watershed District

1000 PENNINGTON AVE.
THIEF RIVER FALLS, MN 56701 (218) 681-5800

THIEF RIVER FALLS FLOOD DAMAGE REDUCTION PROJECT AND IMPROVEMENT TO PENNINGTON COUNTY DITCH #1 (RLWD DITCH #14)

BELLEVILLE COURT
STORM SEWER PLAN AND PROFILE
STA 1500+00 TO 1501+42
AS-BUILT - JANUARY 2013

0 1/2" 1"

FILENAME OOC-UT06-01.dwg SHEET UT-26